



1" IF THIS BAR DOES NOT MEASURE EXACTLY ONE INCH, THE SCALE OF THIS DRAWING HAS BEEN ALTERED DURING ITS PRODUCTION, AFFECTING ALL LABELED SCALES


4/17/2025 3:35:47 PM Autodesk Docs//10297.24002-CBY Airport Water System Extension/INF-MECH-10297.24002_RV23.rvt

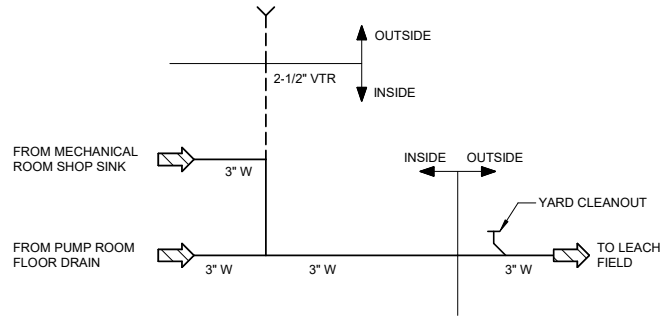


1 WASTE AND VENT SYSTEM DIAGRAM
M-511 SCALE: NO SCALE

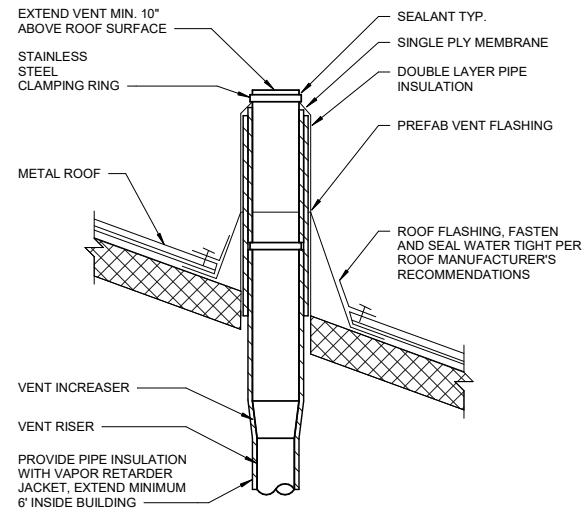


4 VENT THROUGH ROOF DETAIL
M-511 SCALE: NO SCALE

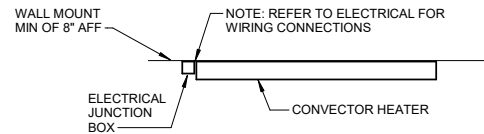


7 ELECTRIC CONVECTOR HEATER DETAIL
M-511 SCALE: NO SCALE

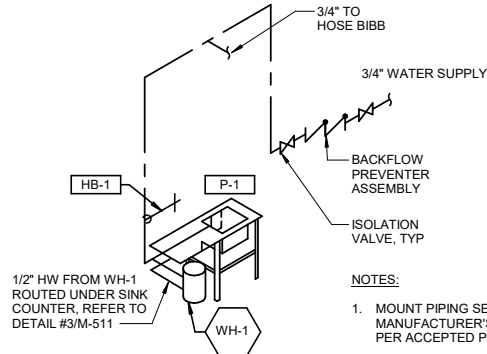


2 WATER PIPING DIAGRAM
M-511 SCALE: NO SCALE

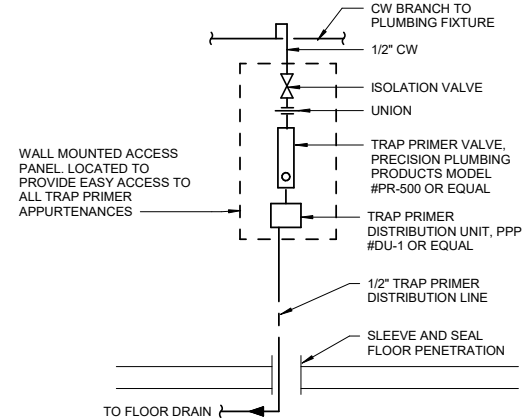

5 TRAP PRIMER DETAIL
M-511 SCALE: NO SCALE

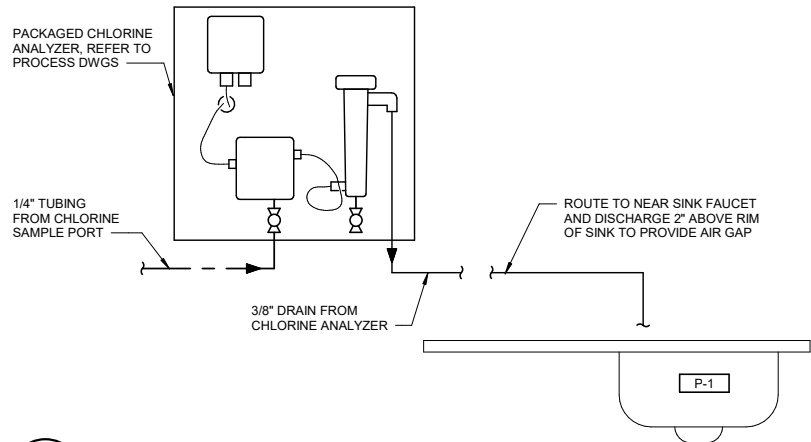


8 CHLORINE ANALYZER PIPING DETAIL
M-511 SCALE: NOT TO SCALE

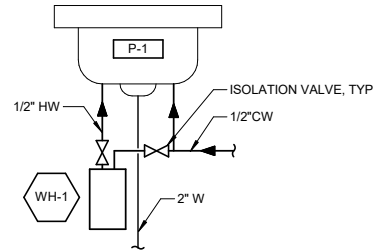

3 WATER HEATER DIAGRAM
M-511 SCALE: NO SCALE

- NOTE:**
1. REFER TO ELECTRICAL FOR WIRING CONNECTIONS.
 2. PROVIDE STRUCTURAL SUPPORT AS REQUIRED.

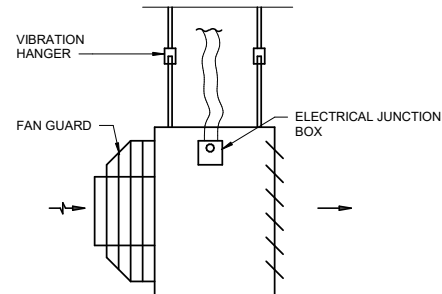

6 ELECTRIC HORIZONTAL UNIT HEATER DETAIL
M-511 SCALE: NO SCALE

CONSULTANT :

Rachel E. Marvin
No. 12598
04/17/2025
REGISTERED PROFESSIONAL ENGINEER
P202124002

Juneau, AK
9103 Mendenhall Mall Rd. Ste 4
Juneau, AK 99801
Phone: 907.780.6060
www.respec.com
AECC163270

PROJECT :

CITY & BOROUGH OF YAKUTAT
WATER SYSTEM EXTENSION

YAKUTAT, ALASKA

SHEET TITLE :

PLUMBING & HEATING DETAILS &
DIAGRAMS

DESIGN	RM
DRAWN	TRS
CHECKED	LAR
DATE	04-16-2025

PROJECT No.
10297.24002

SHEET NUMBER

M-511

No.	Date	Item
REVISIONS		