


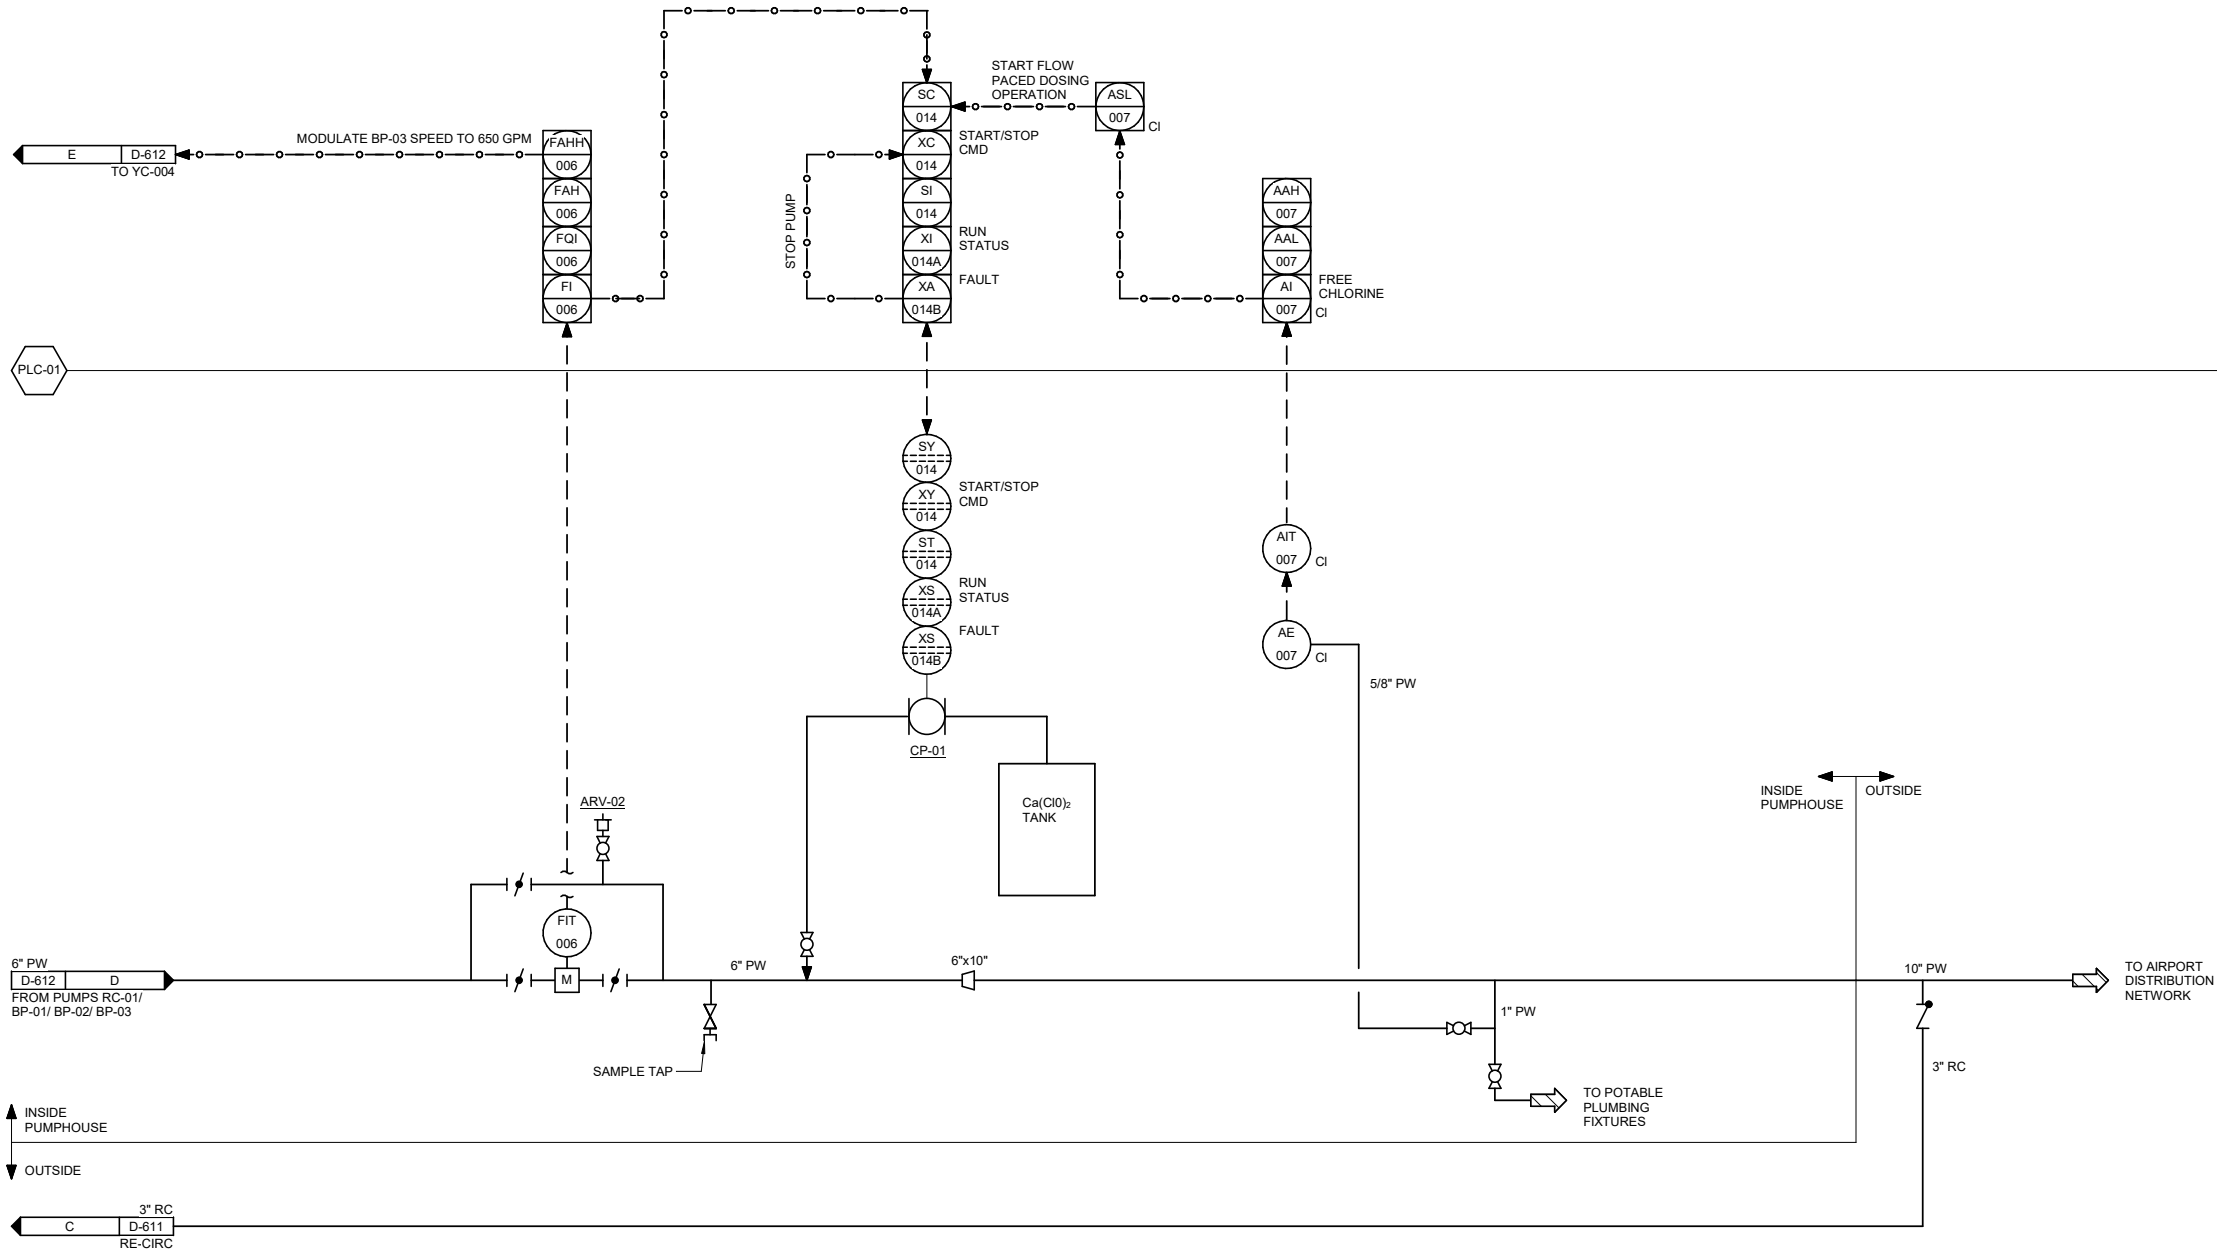

1

WATER TREATMENT P&ID

D-613

SCALE: NO SCALE

No.	Date	Item
REVISIONS		



CONSULTANT :

Juneau, AK

9103 Mendenhall Mall Rd. Ste 4
Juneau, AK 99801
Phone: 907.780.6060
www.respec.com
AECC163270

PROJECT :

CITY & BOROUGH OF YAKUTAT
WATER SYSTEM EXTENSION

YAKUTAT, ALASKA

SHEET TITLE :

WATER TREATMENT P&ID

DESIGN	ALN
DRAWN	TRS
CHECKED	LAR
DATE	04-16-2025

PROJECT No.

10297.24002

SHEET NUMBER

D-613