


4/17/2025 1:11:24 PM Autodesk Docs\\10297.24002\\CBY Airport Water System Extension\\NF-MECH-10297.24002_RV23.rvt IF THIS BAR DOES NOT MEASURE EXACTLY ONE INCH, THE SCALE OF THIS DRAWING HAS BEEN ALTERED DURING ITS PRODUCTION. AFFECTING ALL LABELED SCALES 1"

1
D-111

PROCESS SITE PLAN

SCALE: 1/4" = 1'-0"

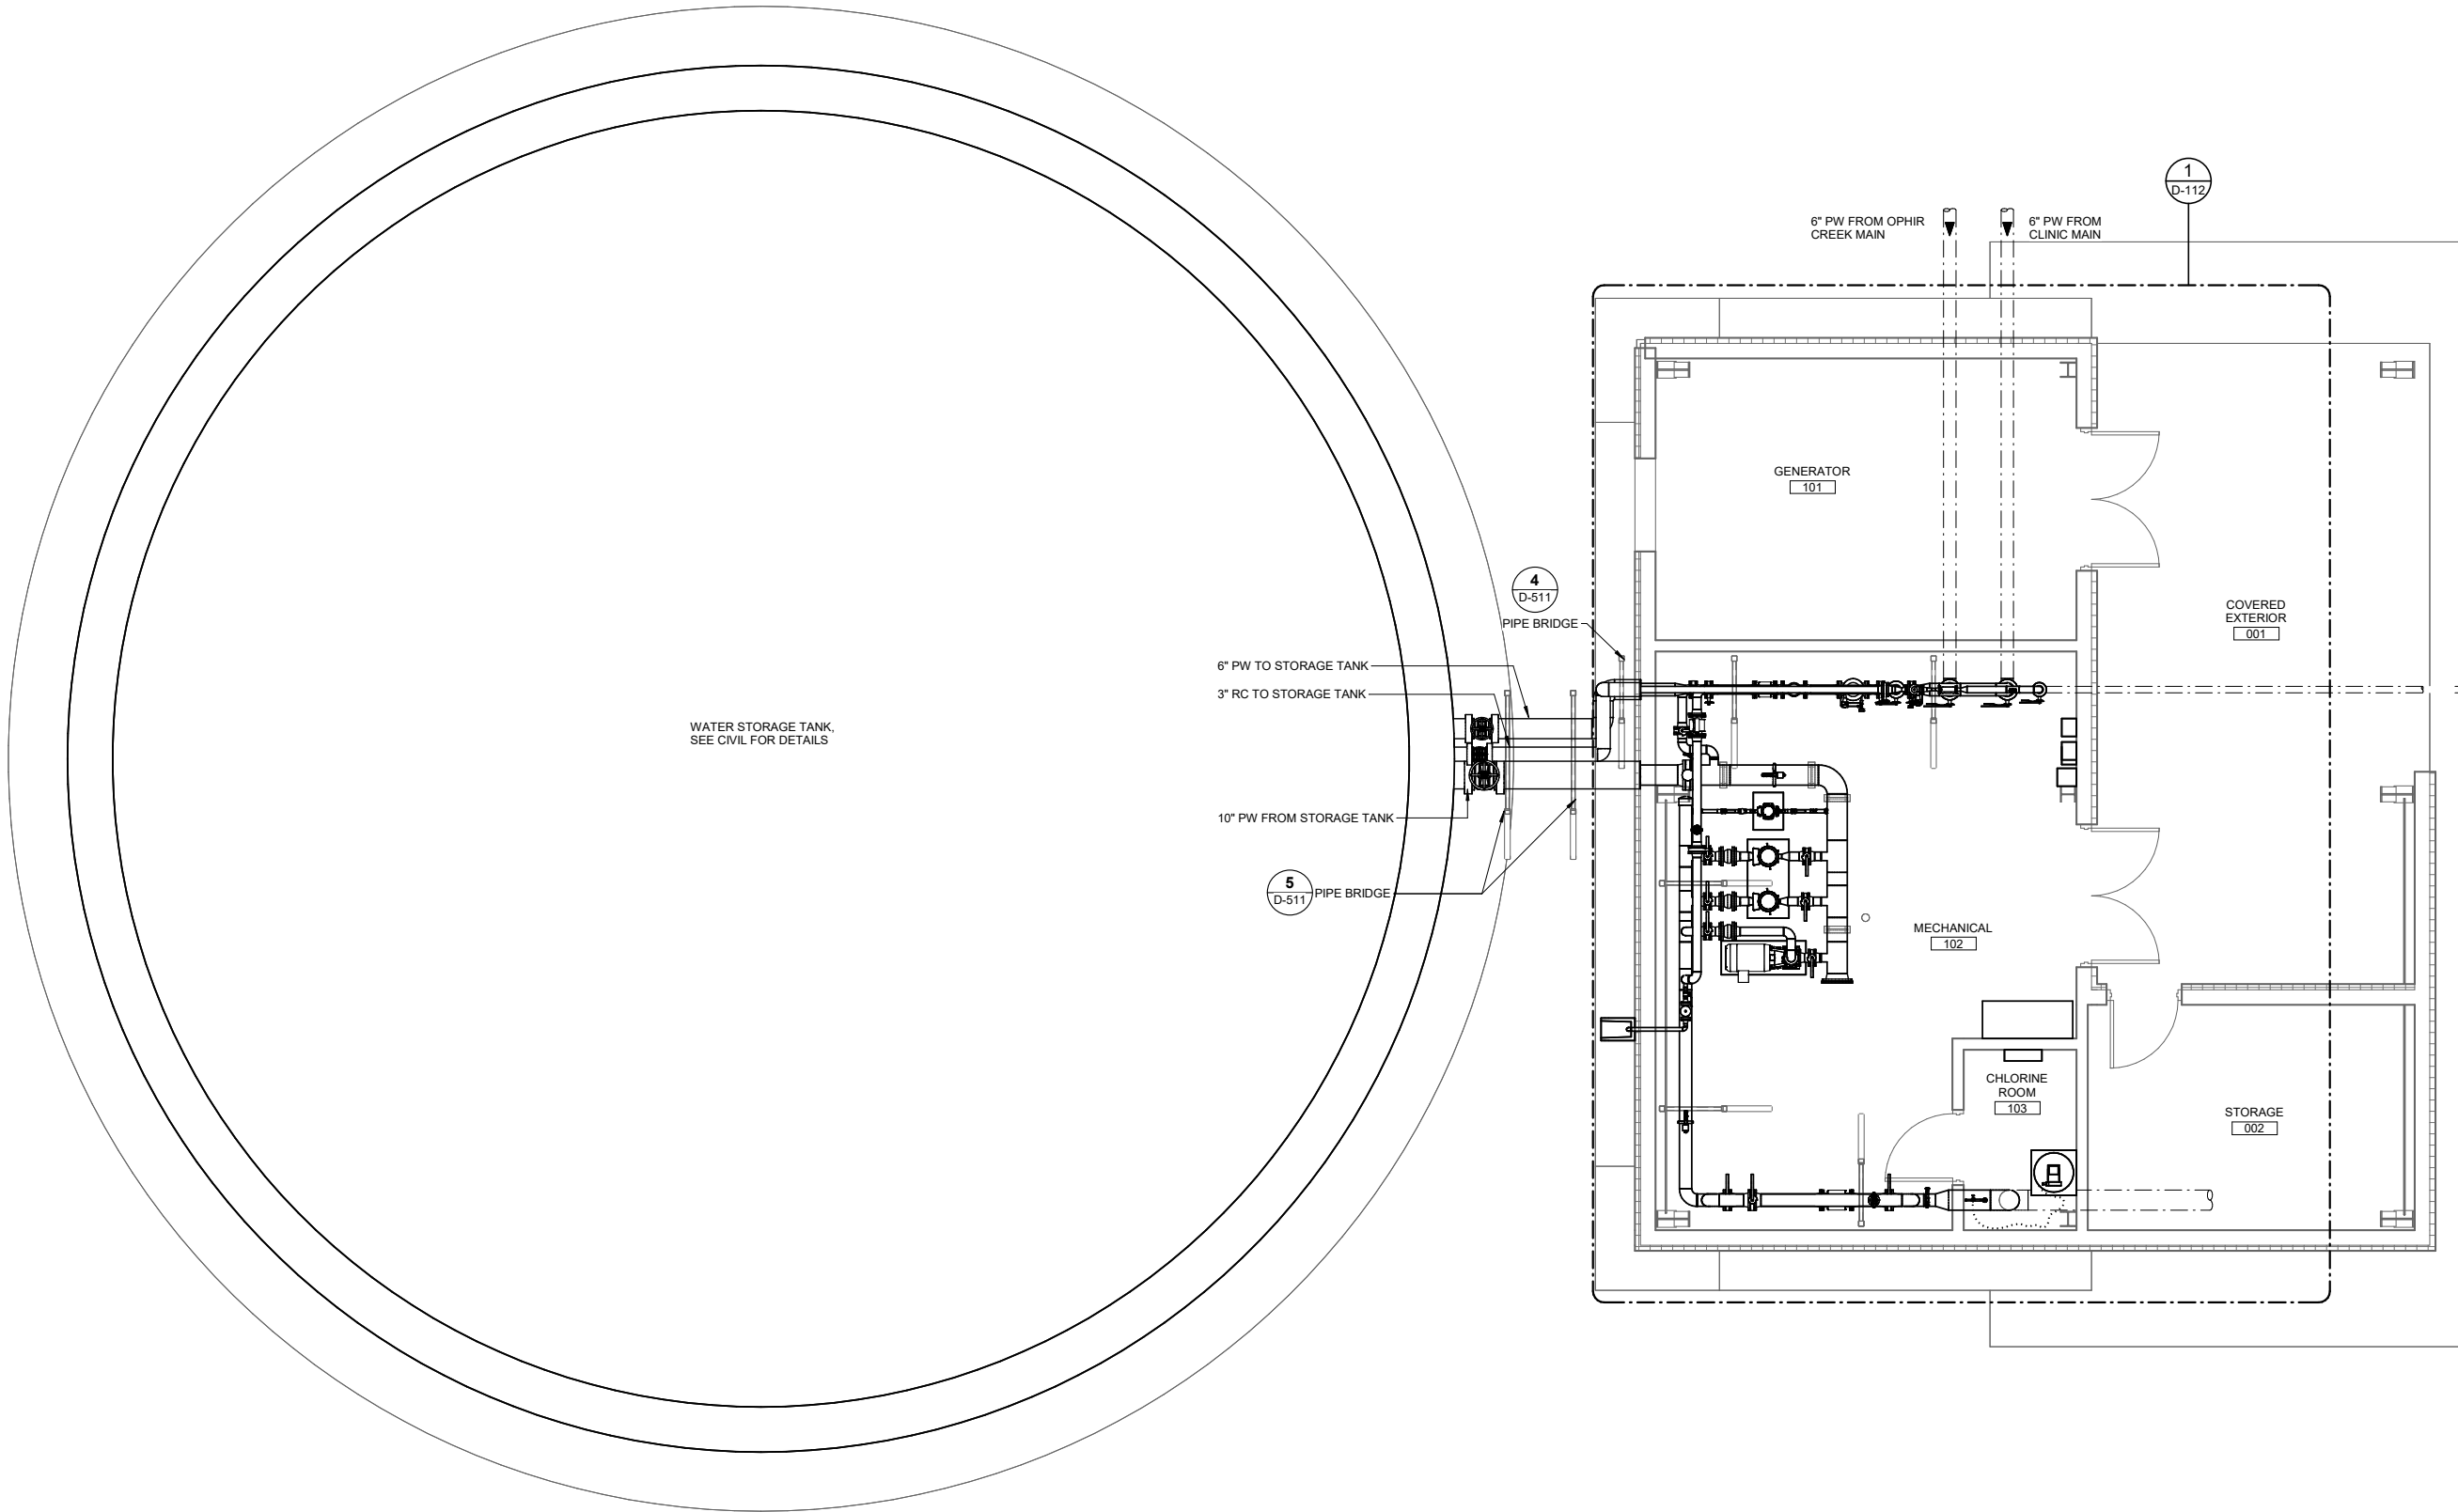

No.	Date	Item
REVISIONS		

SHEET TITLE :

SITE PLAN - PROCESS

PROJECT :

CITY & BOROUGH OF YAKUTAT
WATER SYSTEM EXTENSION

YAKUTAT, ALASKA

DESIGN	ALN
DRAWN	TRS
CHECKED	LAR
DATE	04-16-2025

PROJECT No.
10297.24002
SHEET NUMBER

D-111

CONSULTANT :



RESPEC
Juneau, AK
9103 Mendenhall Mall Rd. Ste 4
Juneau, AK 99801
Phone: 907.780.6060
www.respec.com
AECC163270