


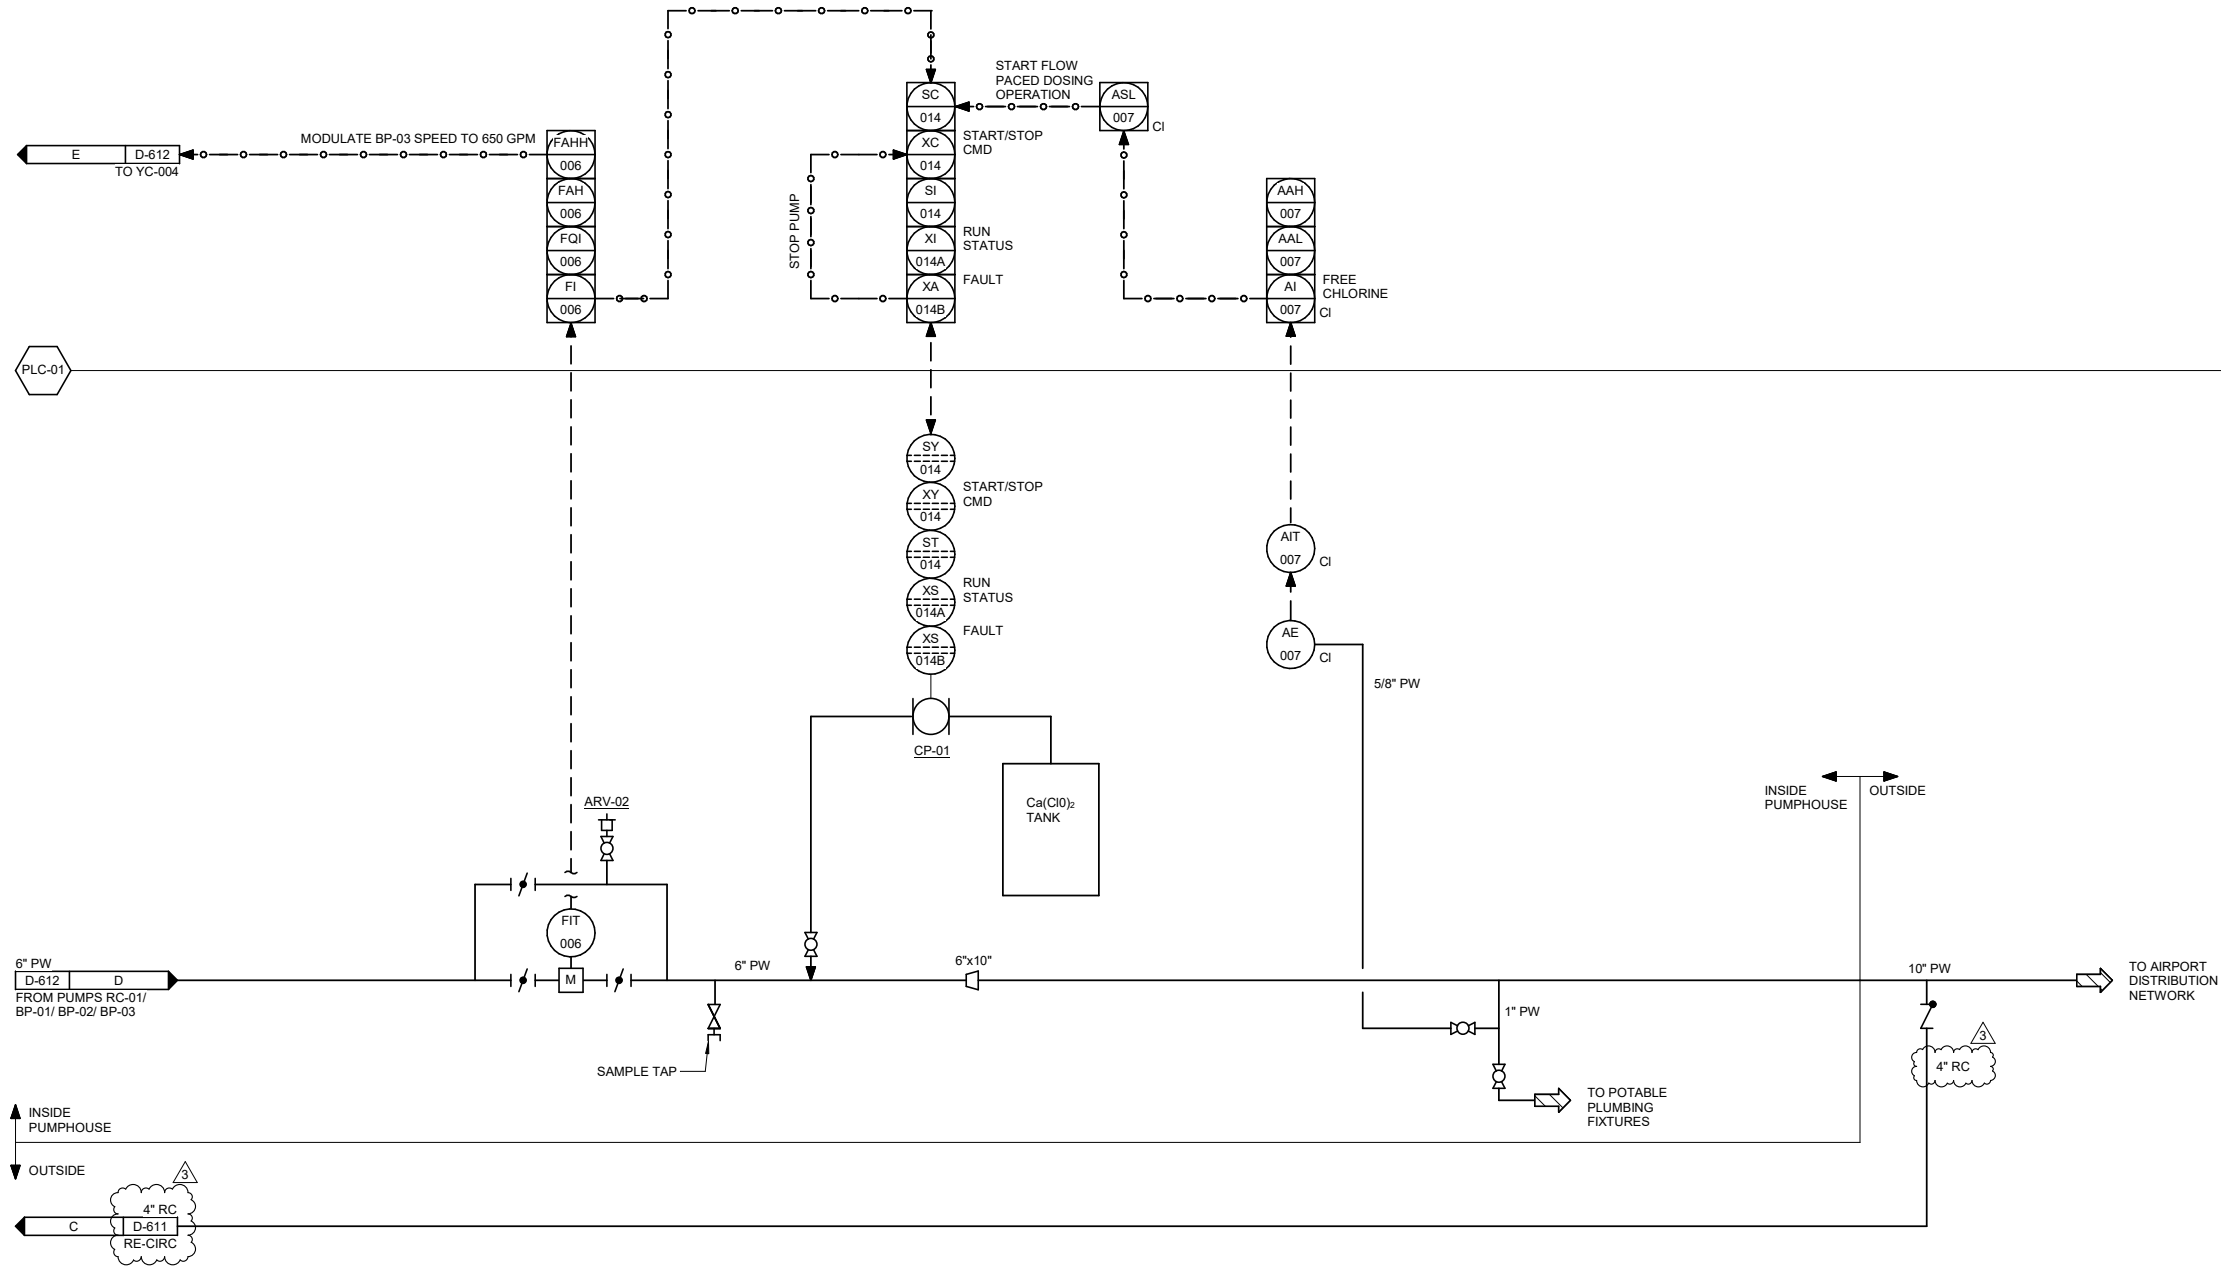

1 WATER TREATMENT P&ID
D-613 SCALE: NO SCALE

3	9/24/25	ADDENDUM #3	
No.	Date	Item	
REVISIONS			



CONSULTANT :

Juneau, AK
9103 Mendernall Mall Rd. Ste 4
Juneau, AK 99801
Phone: 907.780.6060
www.respec.com
AECC163270

PROJECT :

**CITY & BOROUGH OF YAKUTAT
WATER SYSTEM EXTENSION**

YAKUTAT, ALASKA

SHEET TITLE :

WATER TREATMENT P&ID

DESIGN	ALN
DRAWN	TRS
CHECKED	LAR
DATE	04-16-2025

PROJECT No.	10297.24002
SHEET NUMBER	D-613