


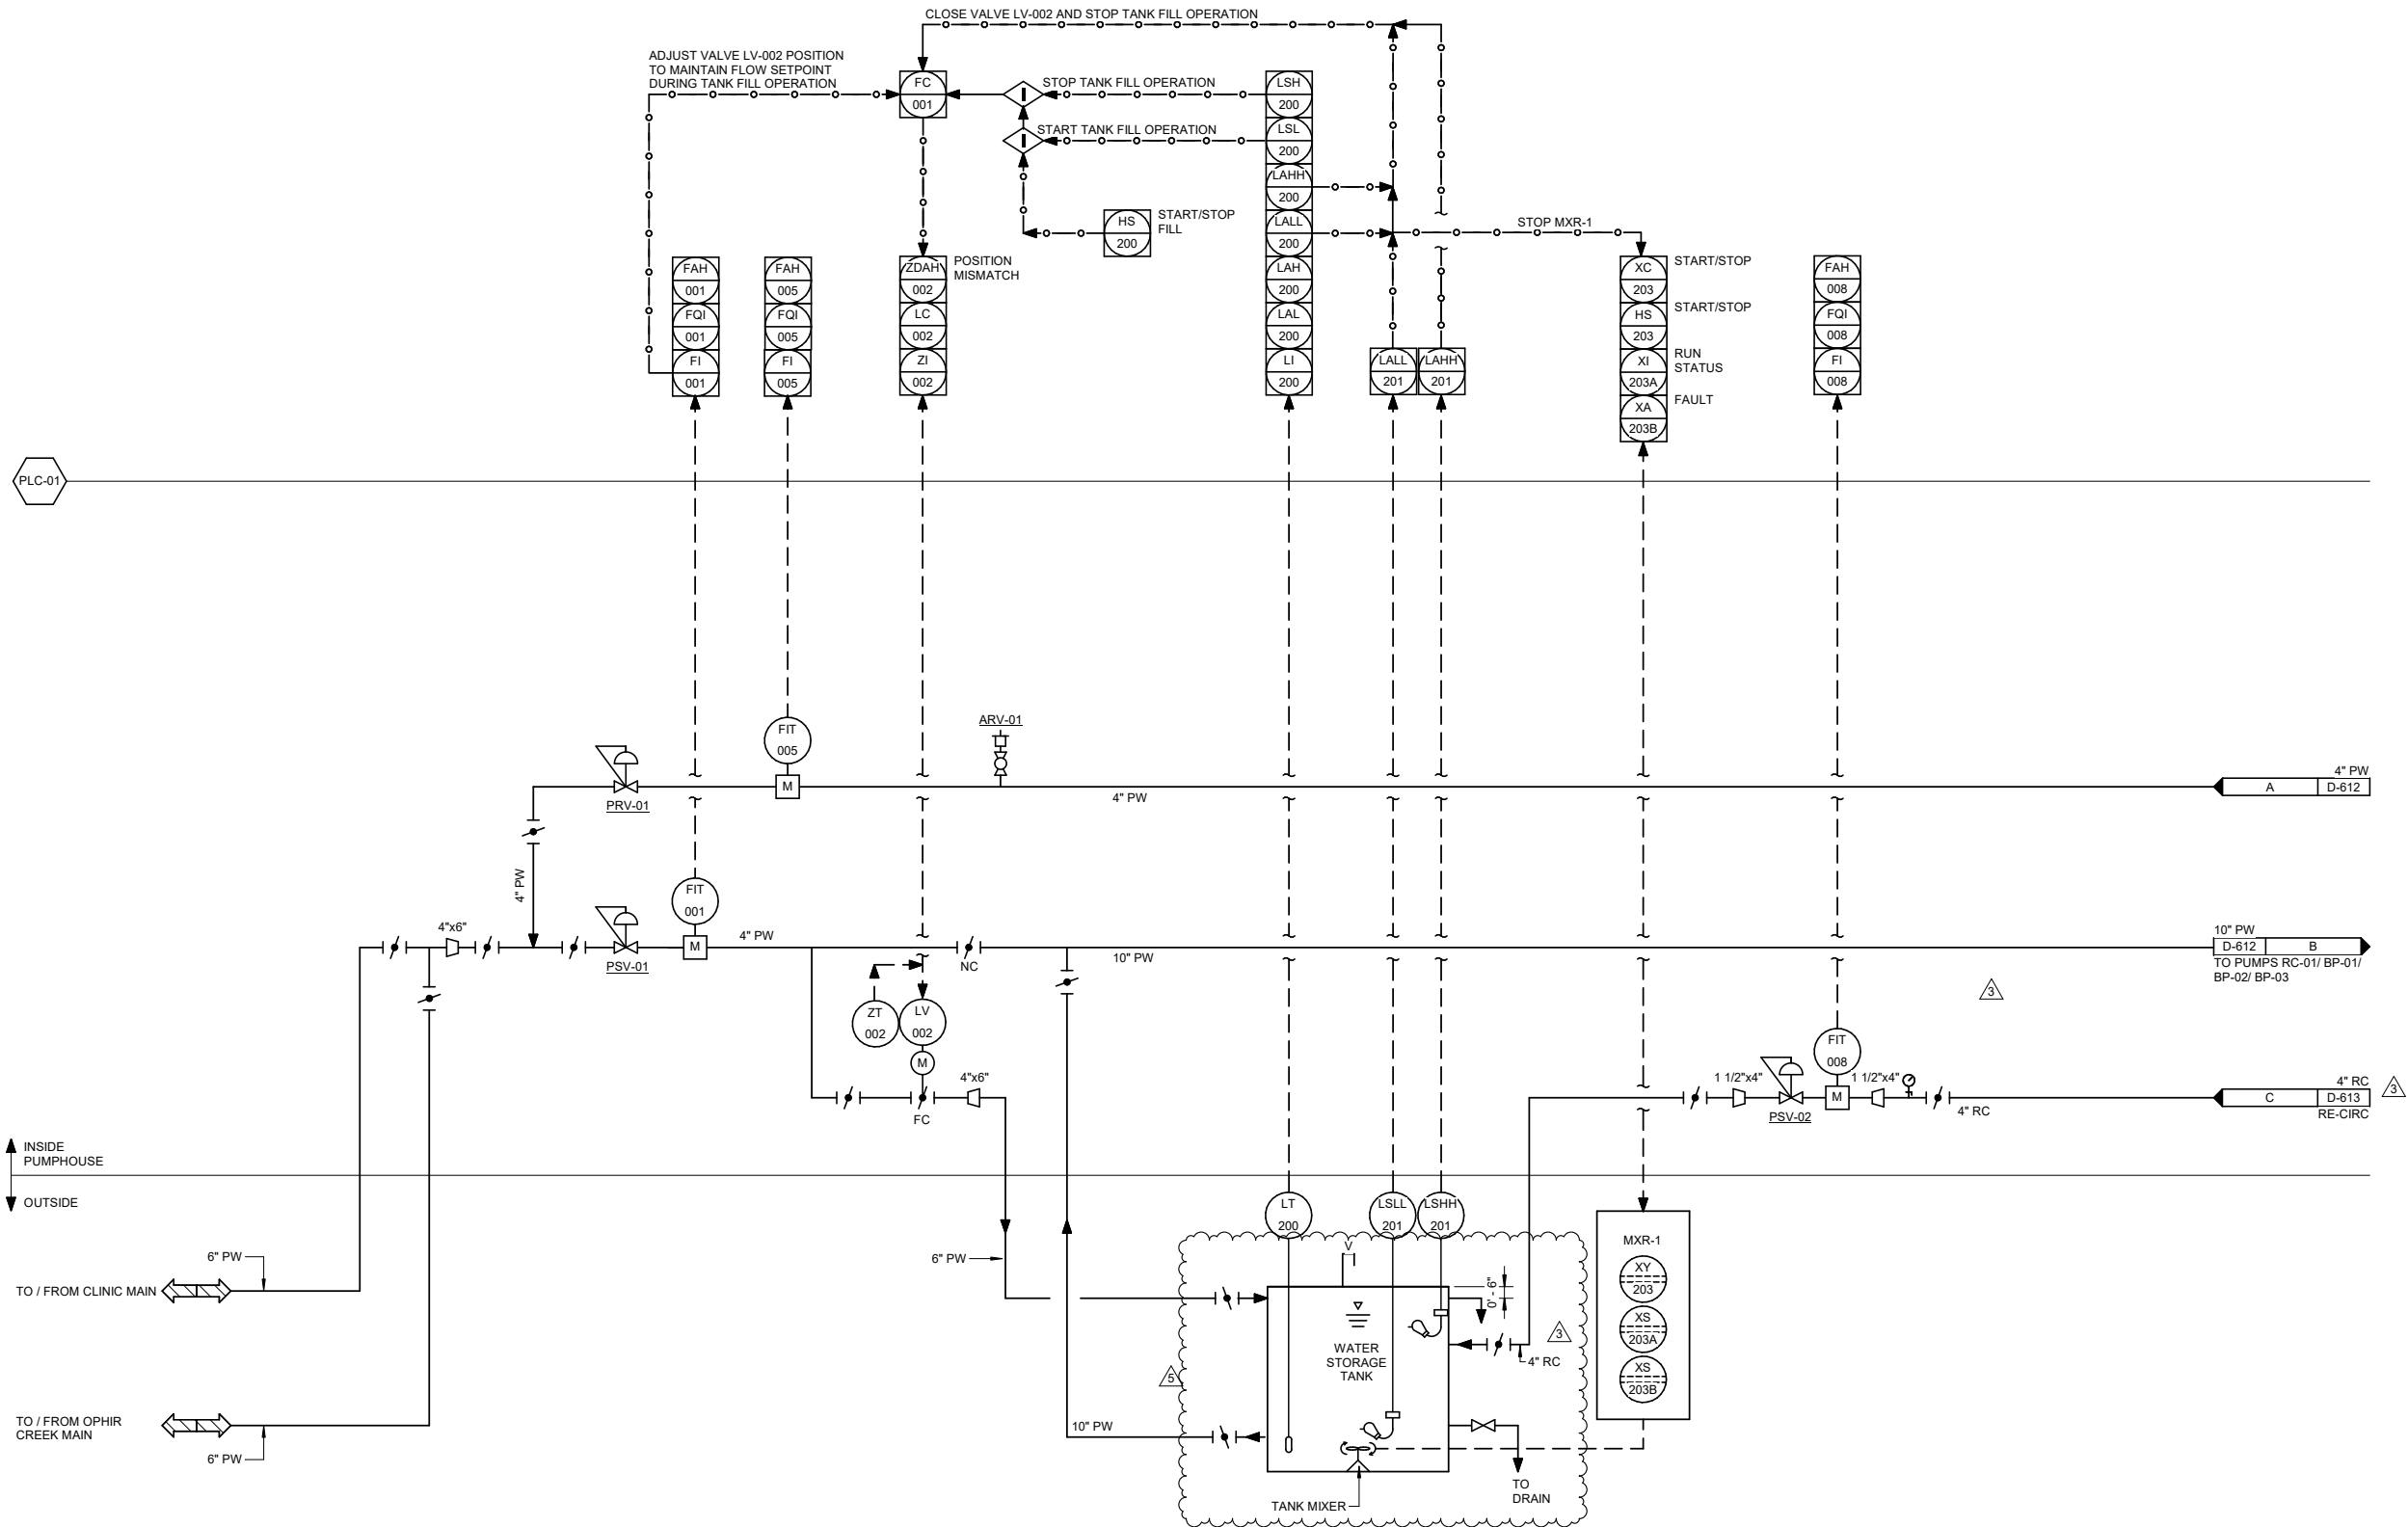

1 WATER TANK P&ID
D-611 SCALE: NO SCALE

3	9/24/25	ADDENDUM #3
5	10/13/25	ADDENDUM #5
No.	Date	Item
REVISIONS		



Juneau, AK
9103 Mendertal Mall Rd. Ste 4
Juneau, AK 99801
Phone: 907.780.6060
www.respec.com
AECC163270

RESPEC

PROJECT :
CITY & BOROUGH OF YAKUTAT
WATER SYSTEM EXTENSION
YAKUTAT, ALASKA

SHEET TITLE :
WATER TANK P&ID

DESIGN	ALN
DRAWN	TRS
CHECKED	LAR
DATE	04-16-2025
PROJECT No.	10297.24002
SHEET NUMBER	

D-611