


10/13/2025 3:48:25 PM Autodesk Docs\\10297.24002\\CBY Airport Water System Extension\\NF-MECH-10297.24002_RV23.rvt IF THIS BAR DOES NOT MEASURE EXACTLY ONE INCH, THE SCALE OF THIS DRAWING HAS BEEN ALTERED DURING ITS PRODUCTION. AFFECTING ALL LABELED SCALES 1"

1

PROCESS SITE PLAN

SCALE: 1/4" = 1'-0"

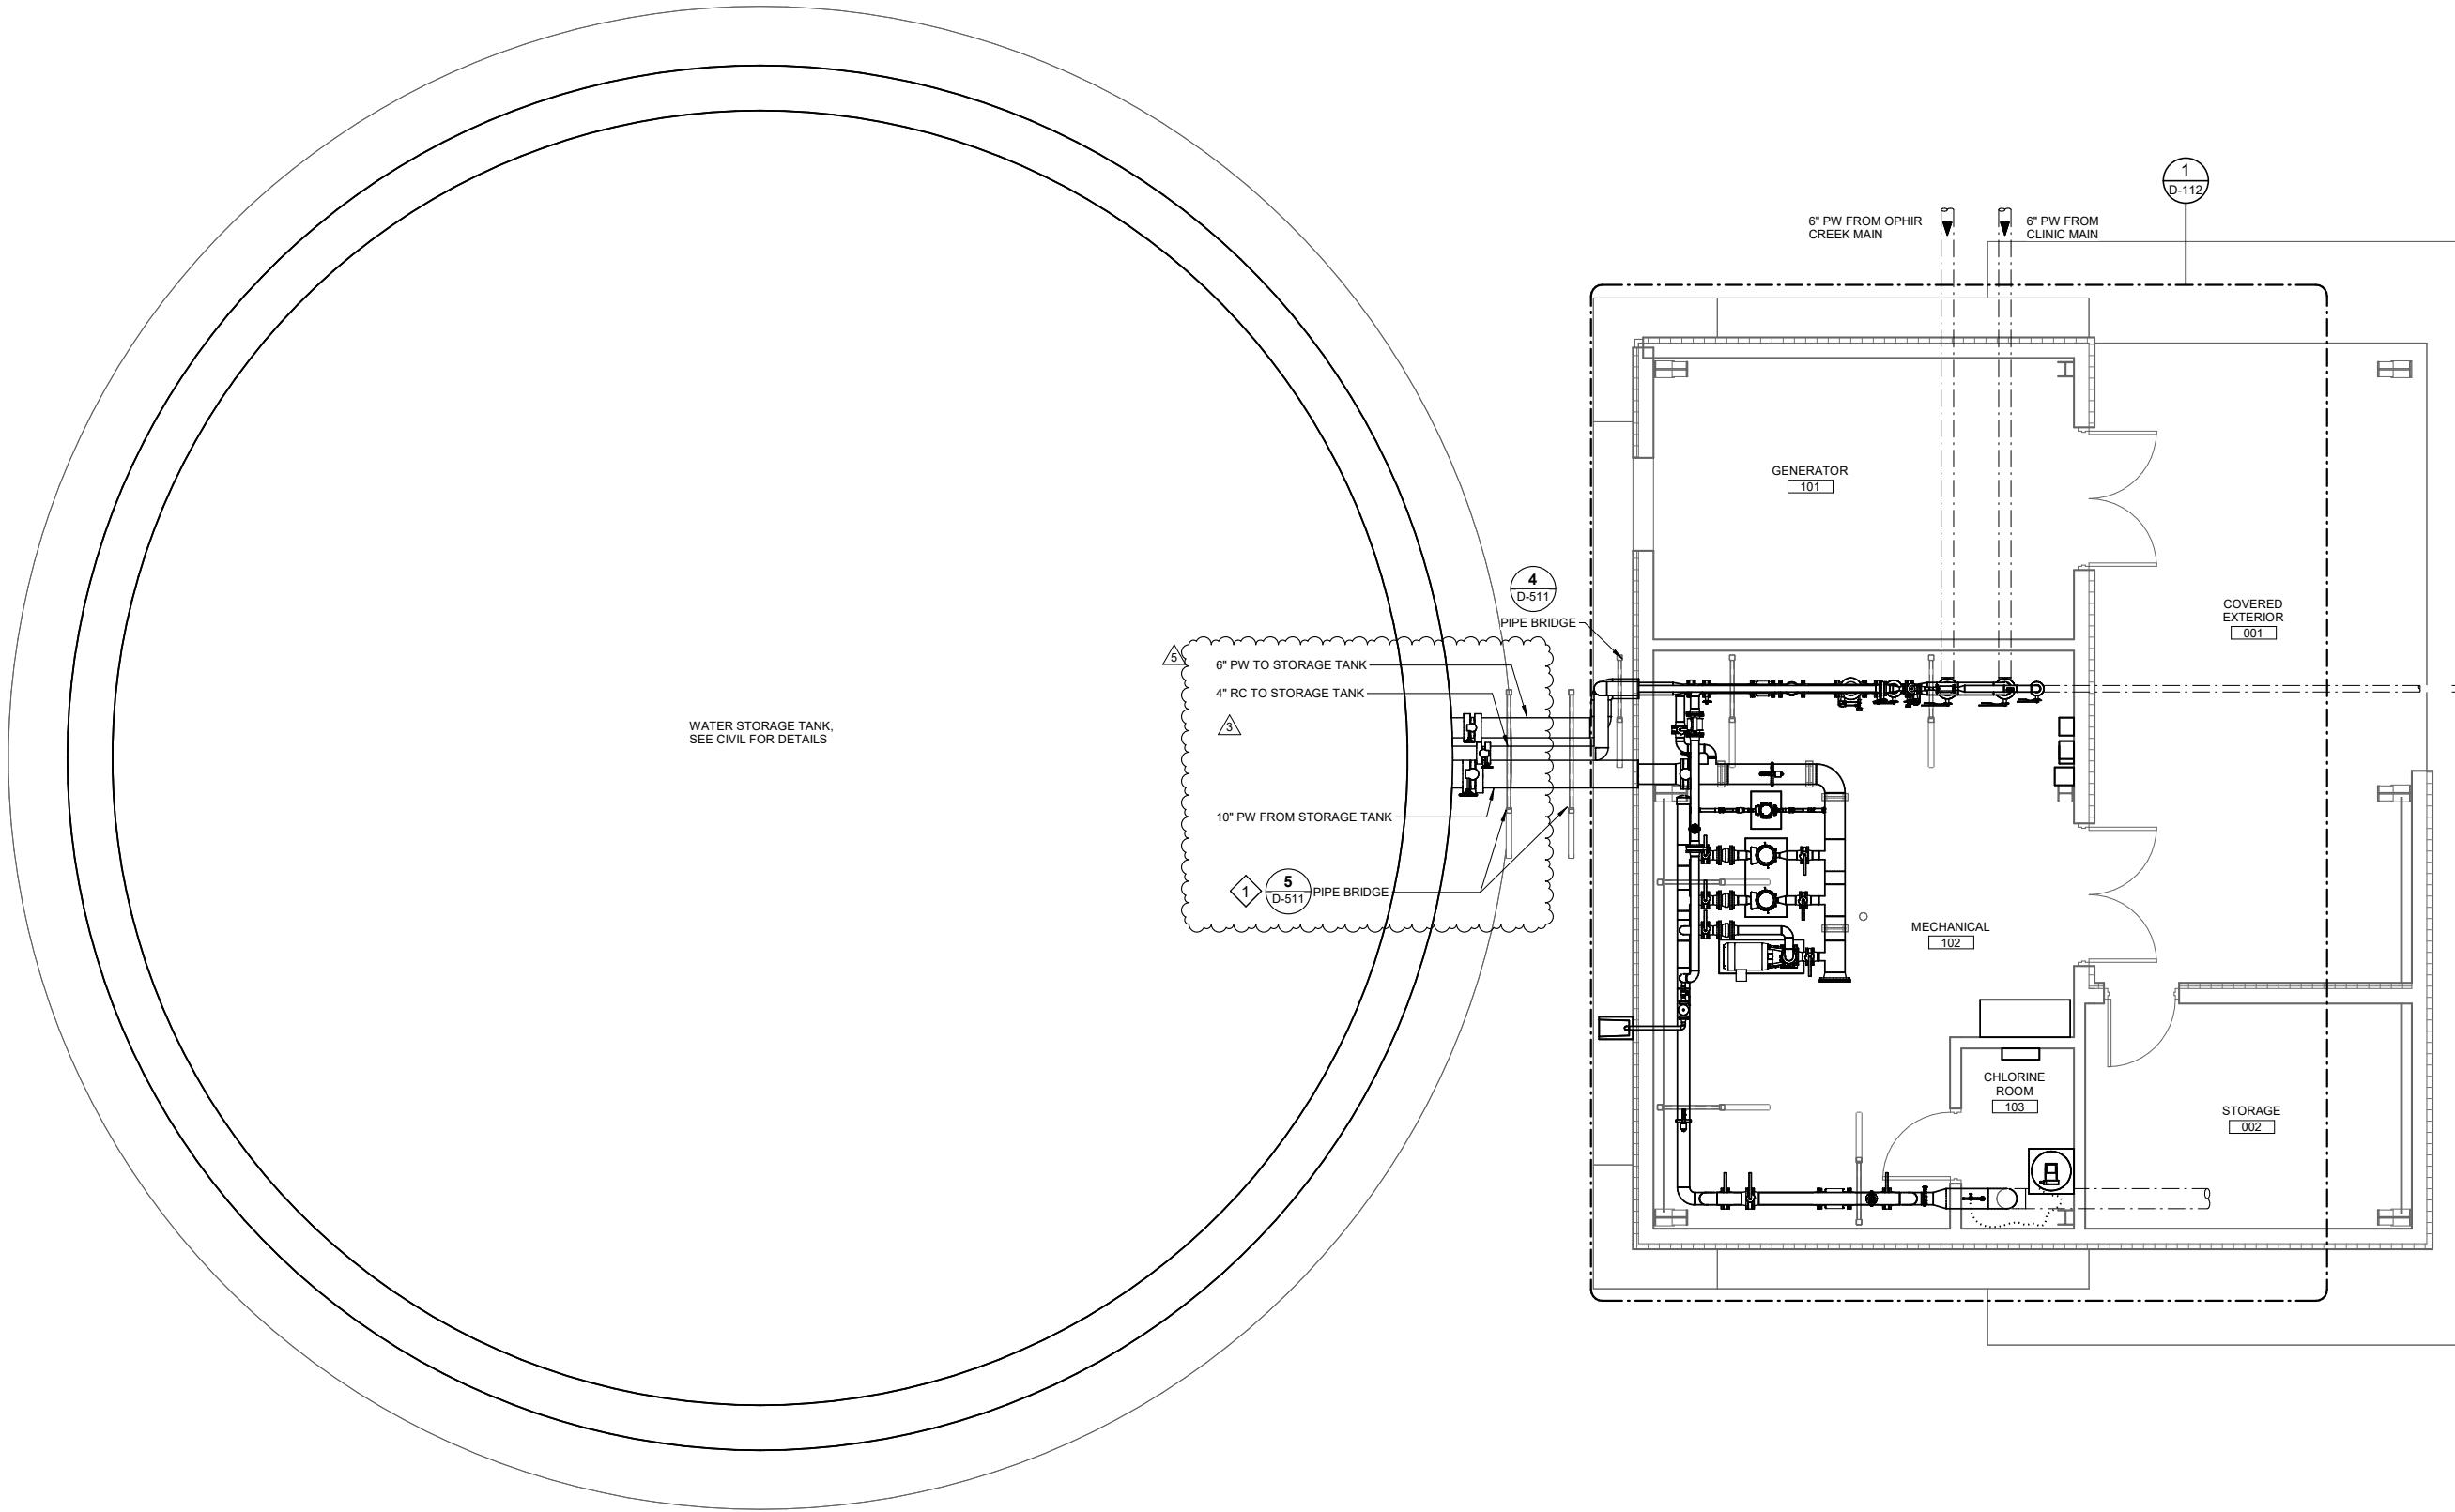

SHEET KEYNOTES

#

1. BRIDGE SPACING TO BE FIELD ADJUSTED TO ACCOMMODATE VALVES AS DIRECTED BY ENGINEER.

REVISIONS			
No.	Date	Item	
3	9/24/25	ADDENDUM #3	
5	10/13/25	ADDENDUM #5	

DESIGN	ALN
DRAWN	TRS
CHECKED	LAR
DATE	04-16-2025

PROJECT No.
10297.24002

SHEET NUMBER

D-111

SHEET TITLE :

SITE PLAN - PROCESS

PROJECT :

CITY & BOROUGH OF YAKUTAT
WATER SYSTEM EXTENSION

YAKUTAT, ALASKA

CONSULTANT :



Juneau, AK
9103 Meridianal Mall Rd. Ste 4
Juneau, AK 99801
Phone: 907.780.6060
www.respec.com
AECC163270