
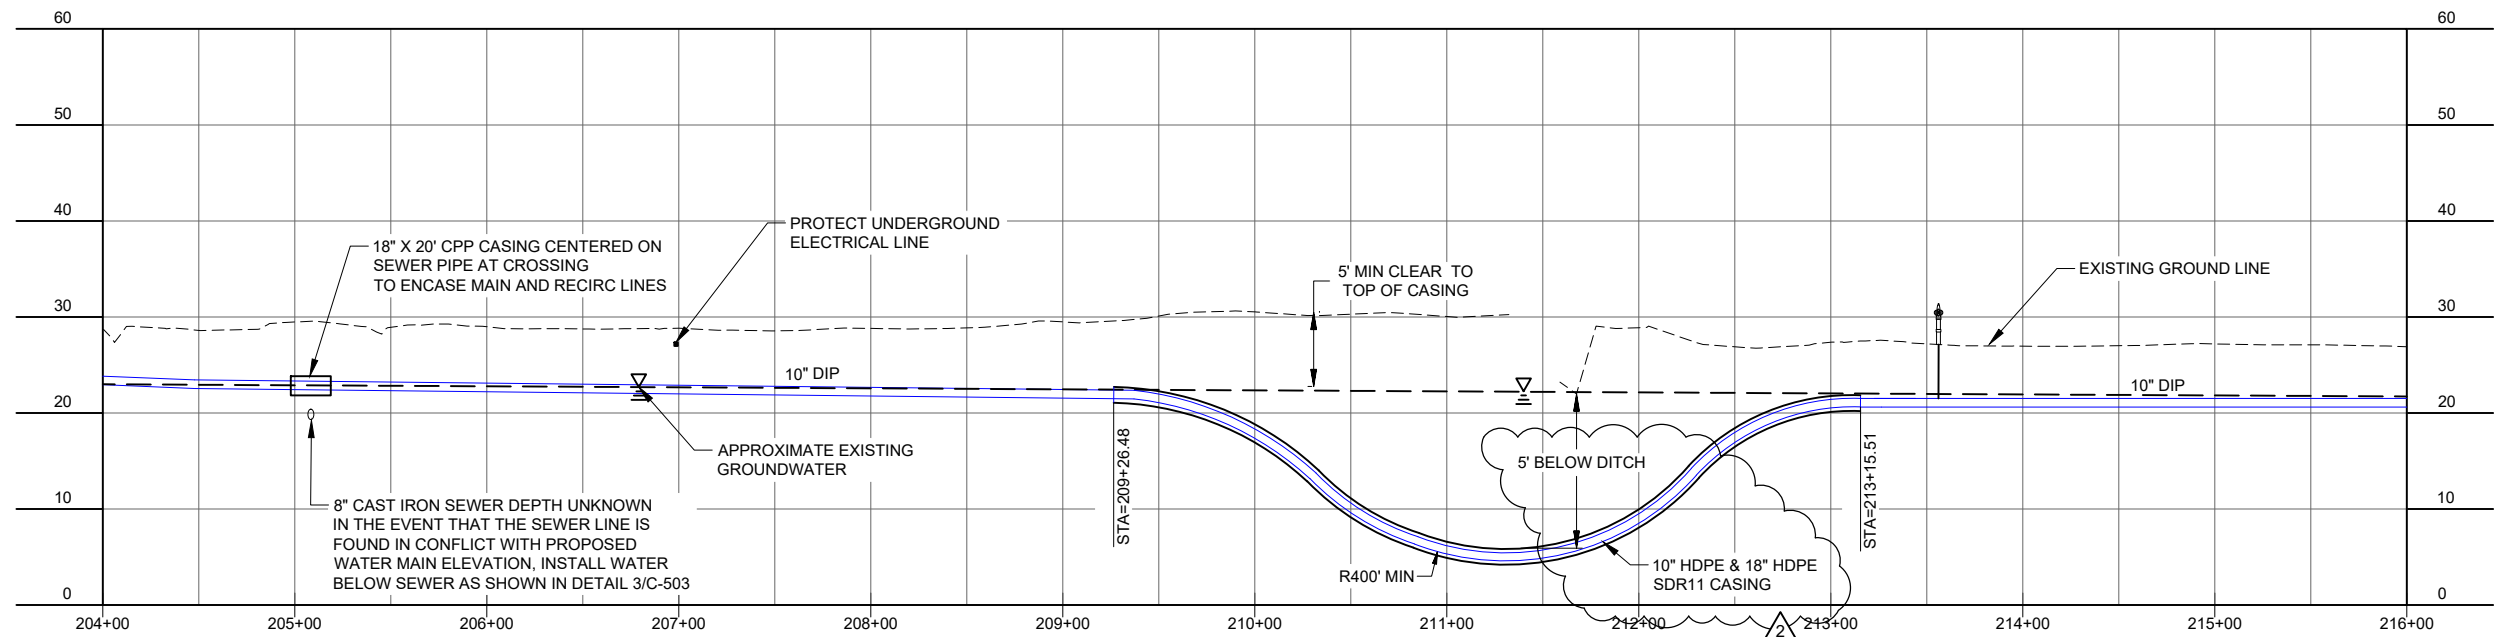


IF THIS BAR DOES NOT MEASURE EXACTLY ONE INCH, THE SCALE OF THIS DRAWING HAS BEEN ALTERED DURING IT'S PRODUCTION, AFFECTING ALL LABELED SCALES

[illegible]

CONSULTANT :

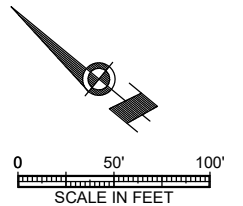

Juneau, AK
9109 Mendenhall Mall Rd., Ste. 4
Juneau, AK 99801
Phone: 907.780.6060
Fax: 907.586.3771
AECC163270



**PROJECT :
CITY & BOROUGH OF YAKUTAT
WATER SYSTEM EXTENSION**

YAKUTAT, ALASKA

SHEET TITLE :
PLAN AND PROFILE -
AIRPORT AREA

DESIGN	AMN
DRAWN	HRB
CHECKED	KAB
DATE	04-16-2025
PROJECT No.	
10297.24002	
SHEET NUMBER	

C-318