


4/17/2025 10:58:09 AM AutodesK Docs//10297.24002-CBY Airport Water System Extension/INF-ELEC-10297.24002\_RV23.vrt IF THIS BAR DOES NOT MEASURE EXACTLY ONE INCH, THE SCALE OF THIS DRAWING HAS BEEN ALTERED DURING IT'S PRODUCTION. AFFECTING ALL LABELED SCALES 1"

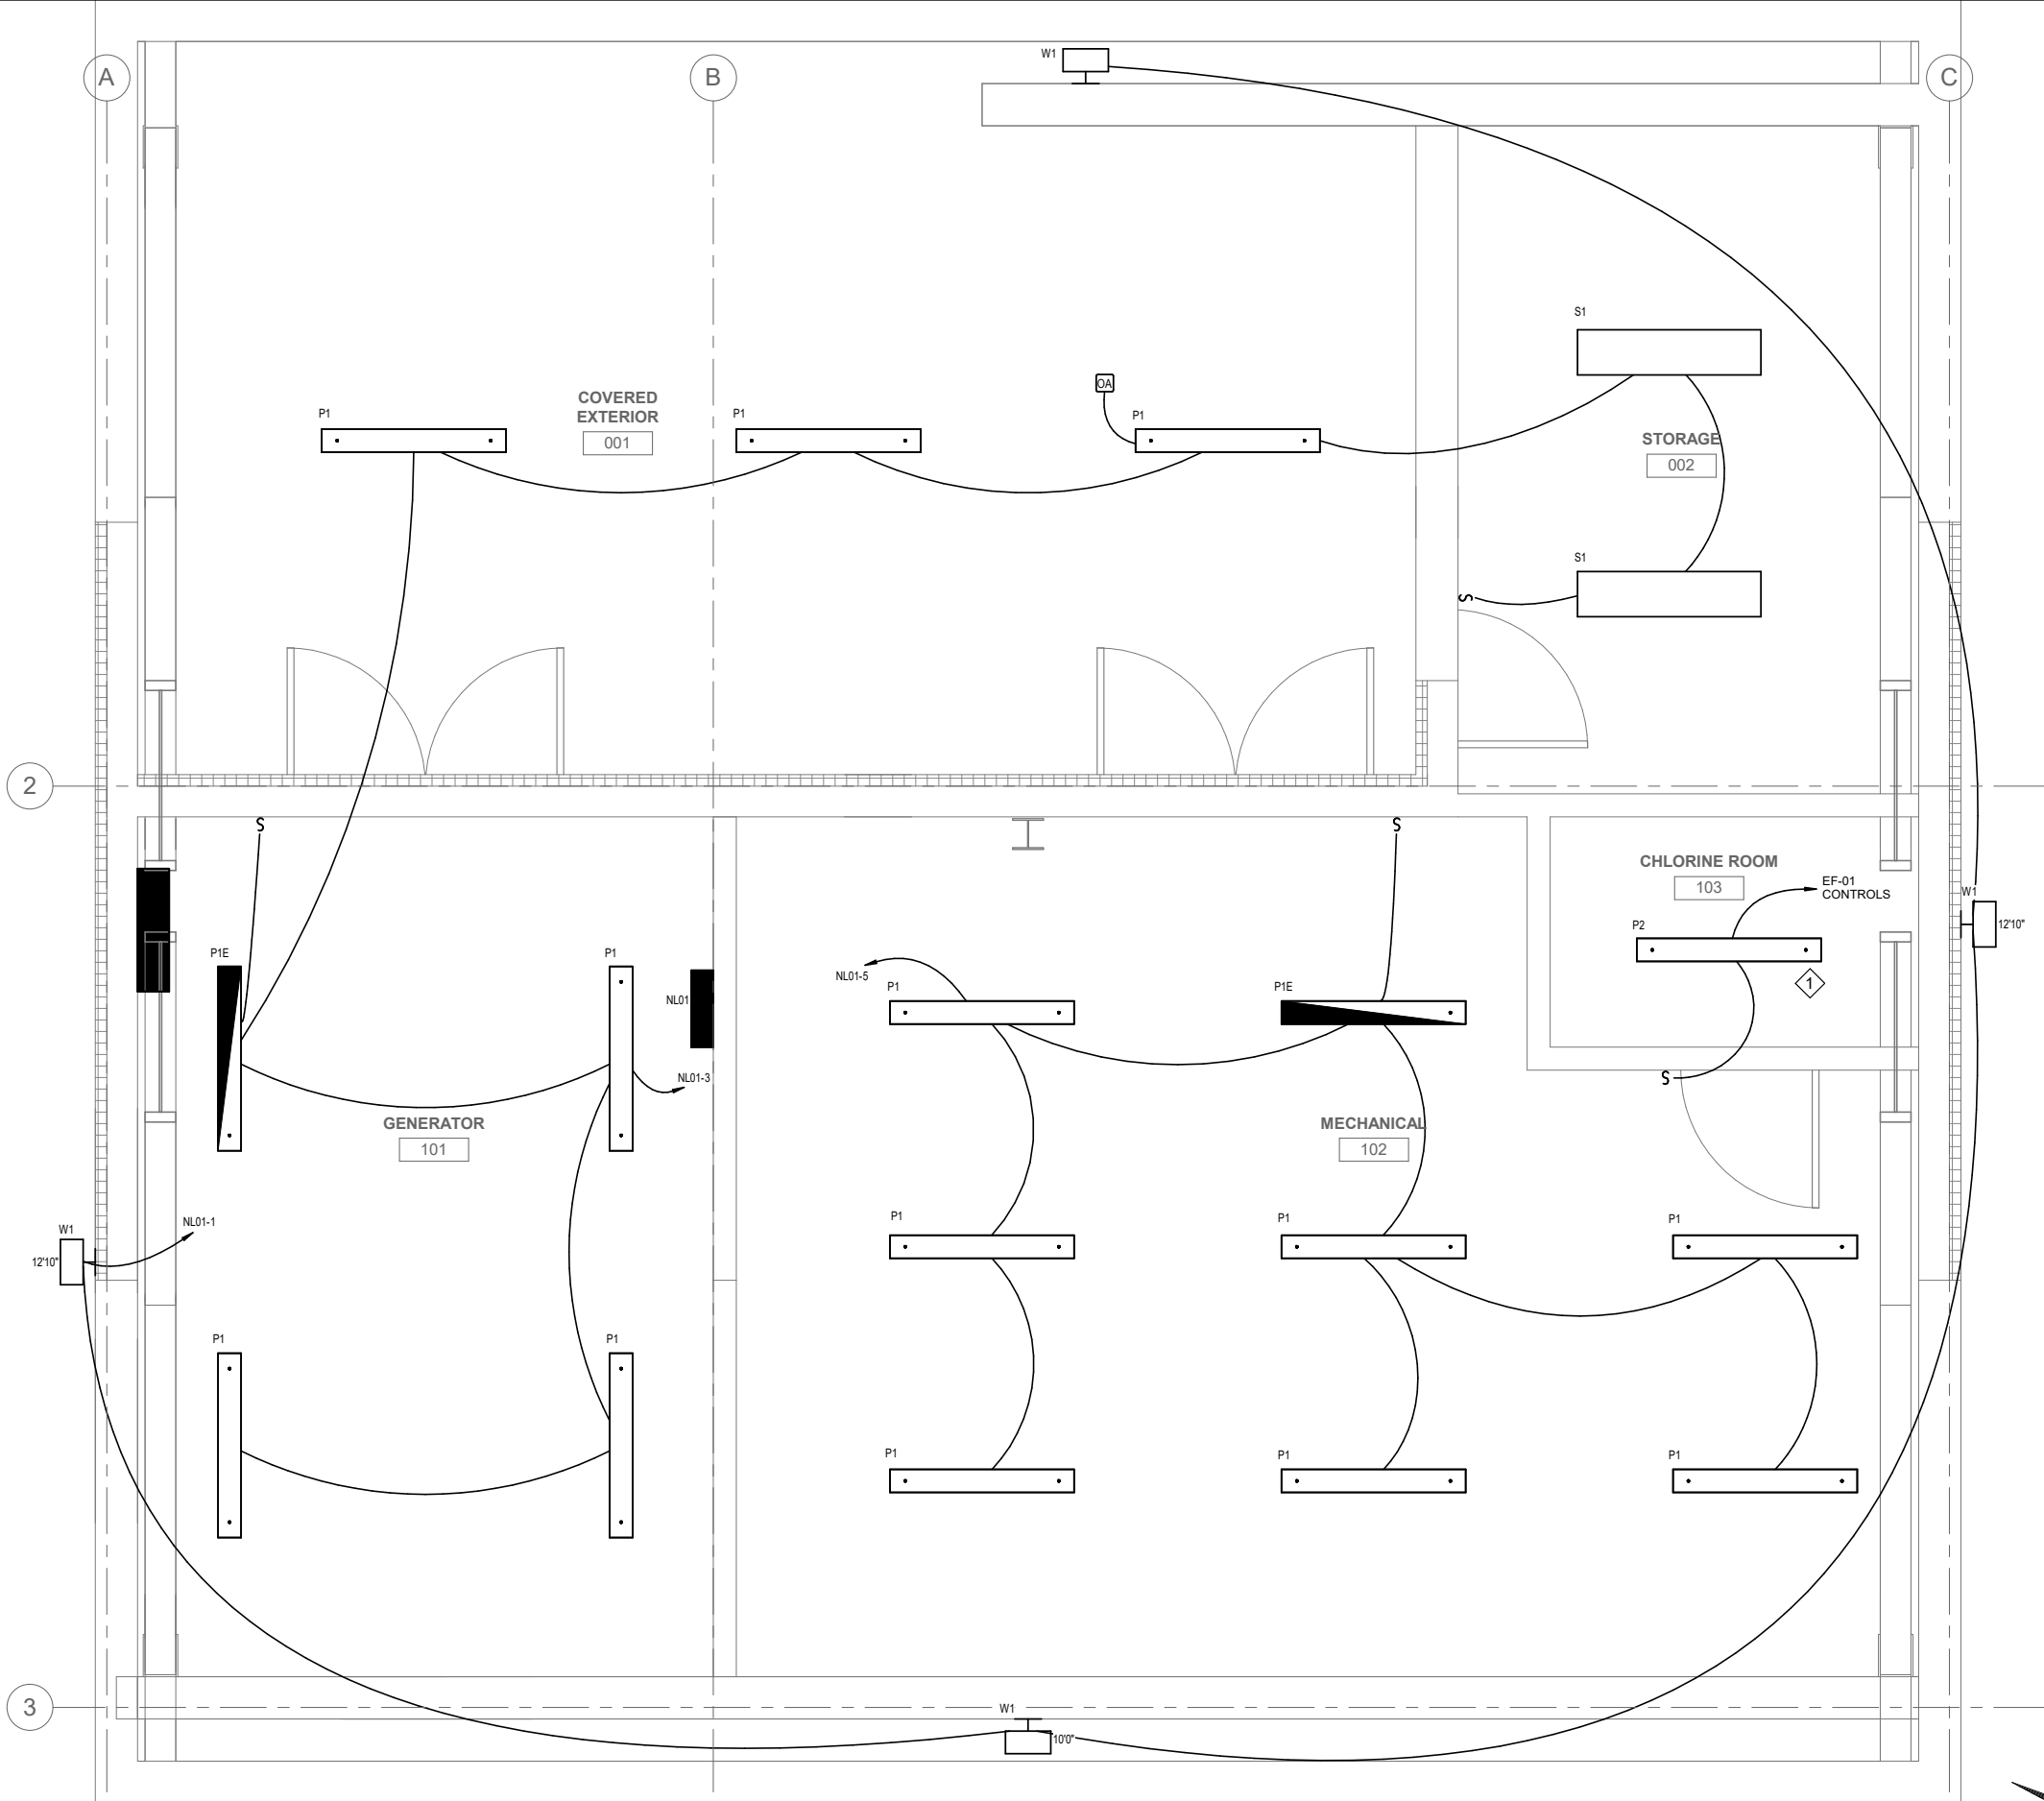

### SHEET KEYNOTES #

1. PROVIDE CONTROLS FOR LIGHTING AND EXHAUST FAN EF-01 USING A LOW VOLTAGE SWITCH OUTSIDE THE ROOM AND AN OCCUPANCY SENSOR INSIDE THE ROOM. THE LIGHT AND EXHAUST FAN SHALL OPERATE WHEN SWITCHED ON AND WHEN OCCUPANCY IS SENSED. THE OCCUPANCY SENSOR SHALL MAINTAIN LIGHT AND EXHAUST FAN OPERATION A MINIMUM OF 20 MINUTES AFTER THE ROOM BECOMES UNOCCUPIED. IF THE ROOM IS NOT OCCUPIED, THE SWITCH MANY OPERATE AND SECURE OPERATION OF THE LIGHT AND EXHAUST FAN WITHOUT DELAYS. REFER TO THE CONTROL DIAGRAM ON SHEET E-502.

## 1 ELECTRICAL FLOOR PLAN - LIGHTING

E-111 SCALE: 1/2" = 1'-0"

| No.       | Date | Item |
|-----------|------|------|
| REVISIONS |      |      |

CONSULTANT :



Juneau, AK  
9103 Wendenhall Mall Rd. Ste 4  
Juneau, AK 99801  
Phone: 907.780.6060  
www.respec.com  
AECC 63270



PROJECT :  
CITY & BOROUGH OF YAKUTAT  
WATER SYSTEM EXTENSION  
YAKUTAT, ALASKA

SHEET TITLE :  
ELECTRICAL FLOOR PLAN -  
LIGHTING

|         |            |
|---------|------------|
| DESIGN  | SH         |
| DRAWN   | CSB        |
| CHECKED | BCH        |
| DATE    | 04-16-2025 |

|              |             |
|--------------|-------------|
| PROJECT No.  | 10297.24002 |
| SHEET NUMBER | E-111       |