

9/24/2025 11:28:20 AM

Autodesk Docs://10297.24002-CBY Airport Water System Extension/INF-MECH-10297.24002_RV23.rvt

1"


IF THIS BAR DOES NOT MEASURE EXACTLY ONE INCH, THE SCALE OF THIS DRAWING HAS BEEN ALTERED DURING ITS PRODUCTION, AFFECTING ALL LABELED SCALES

1

D-111

PROCESS SITE PLAN

SCALE: 1/4" = 1'-0"

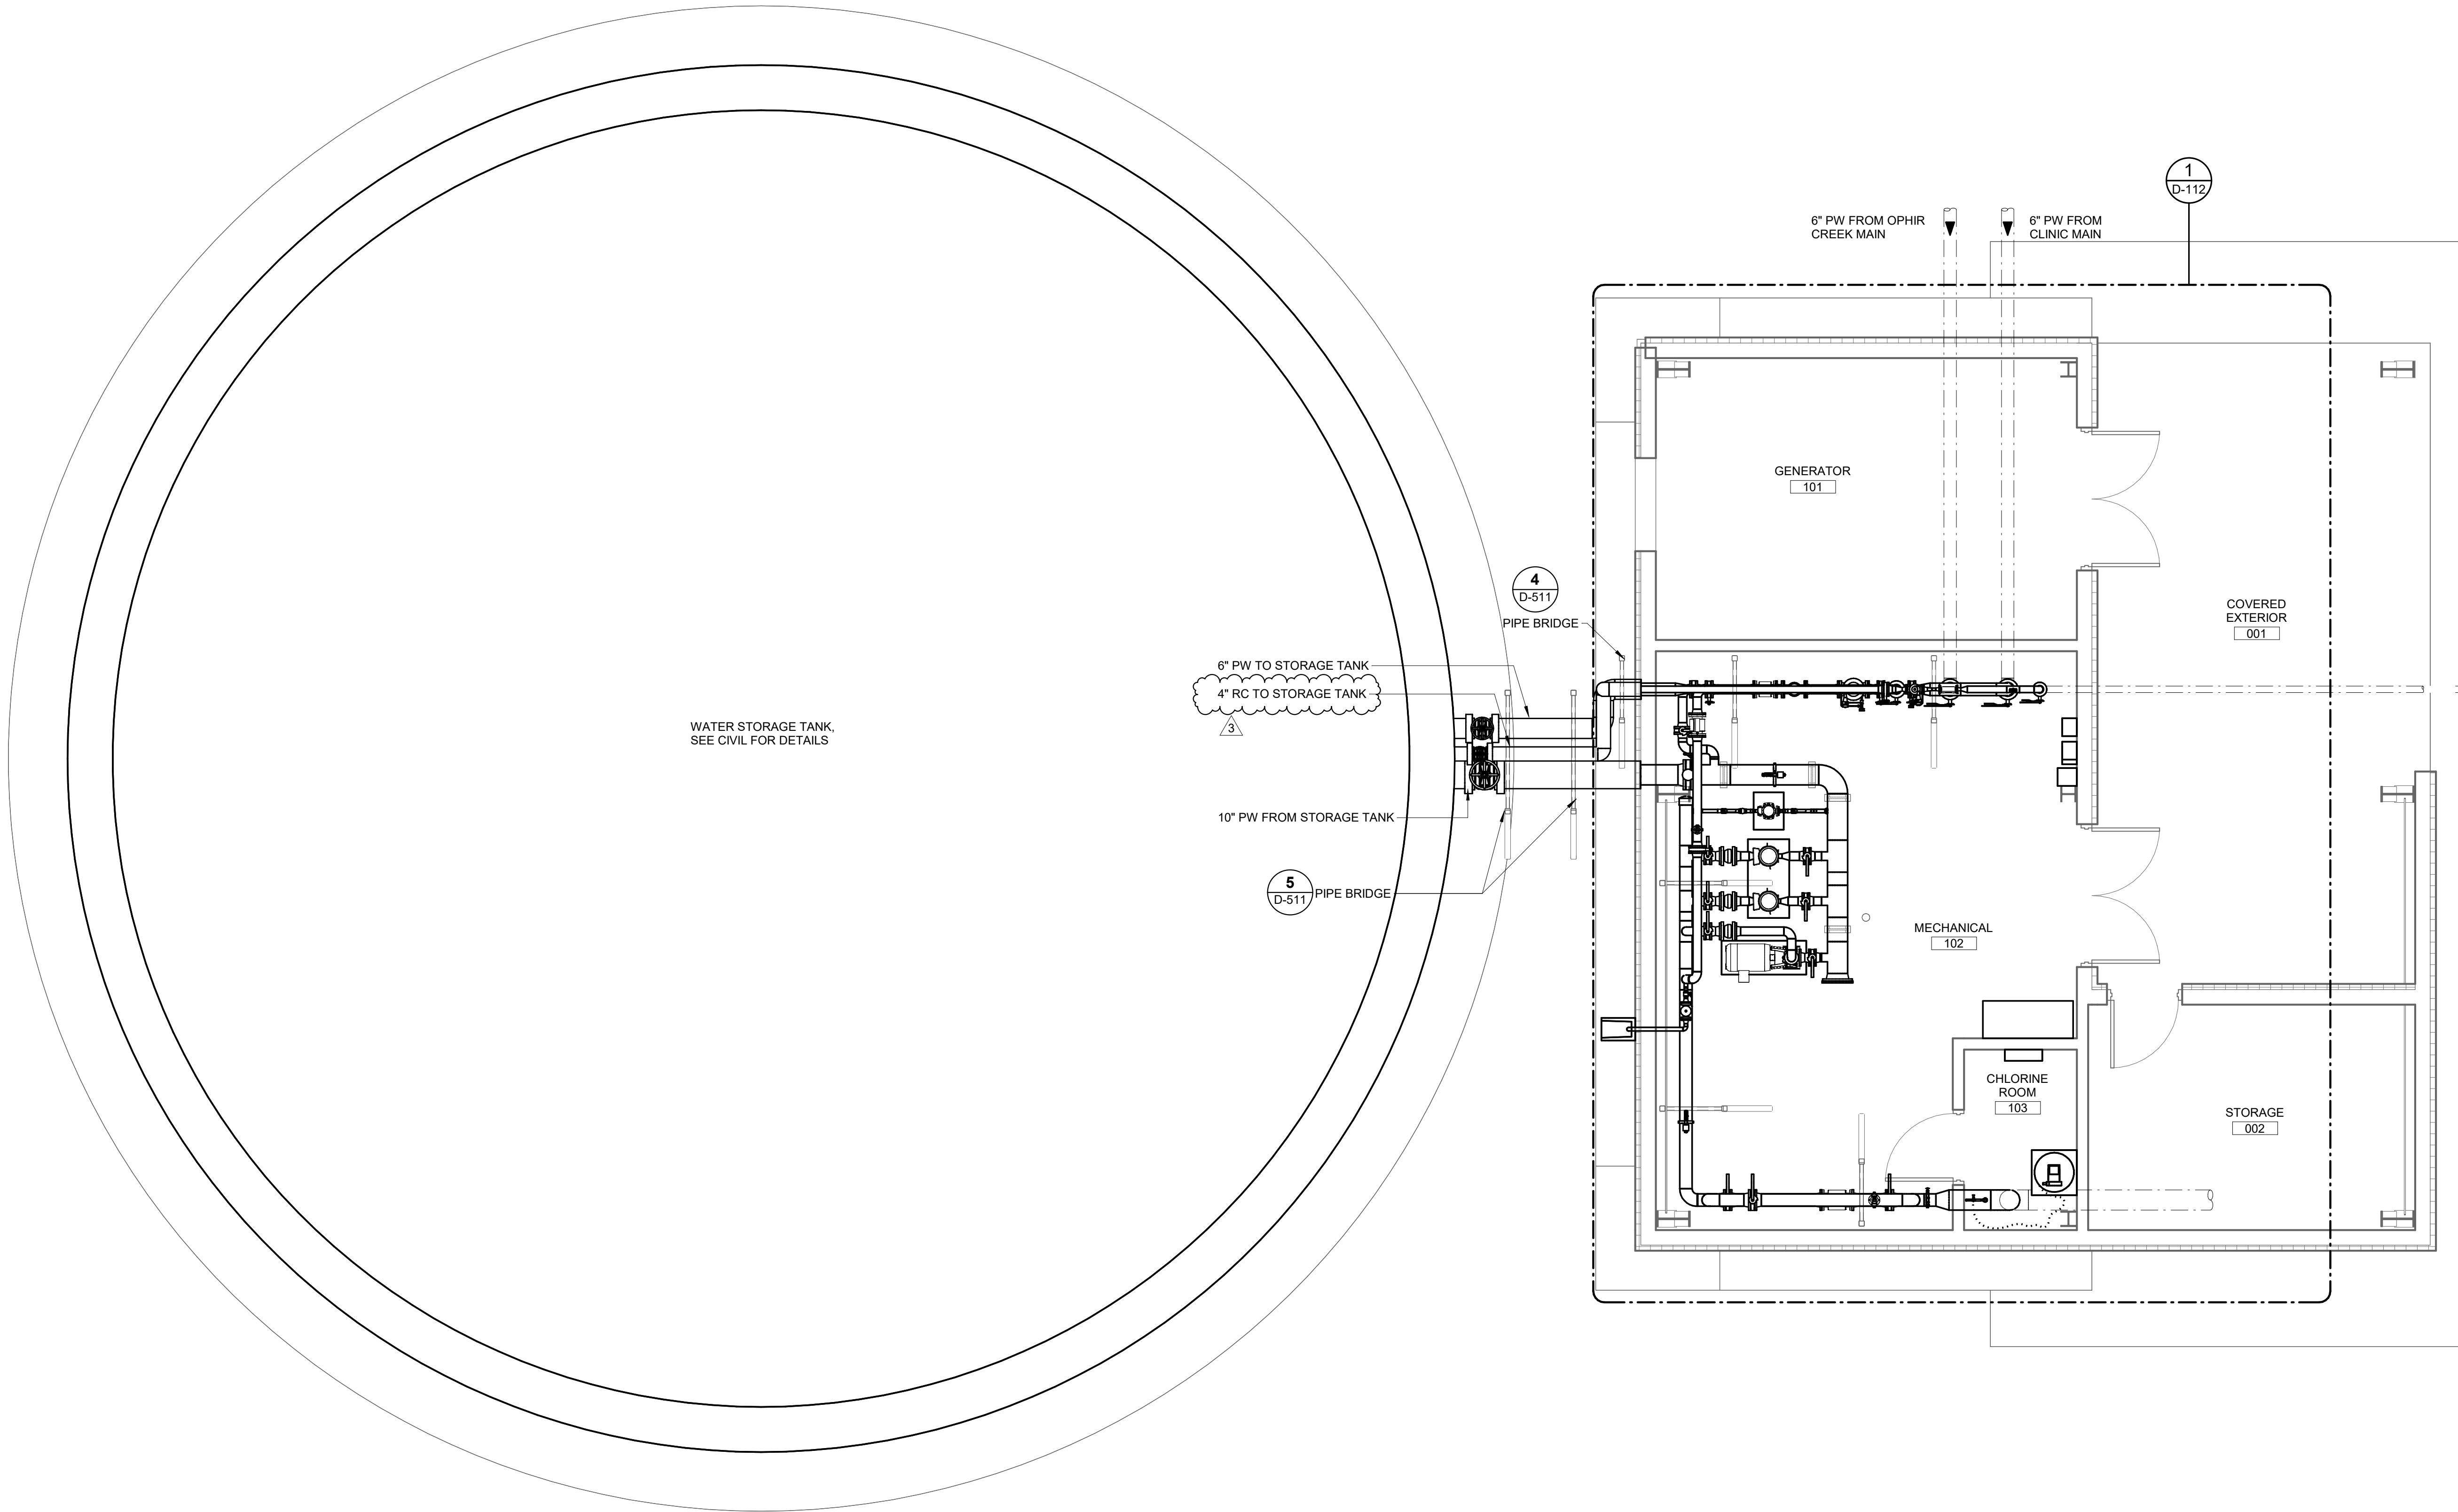

REVISIONS			
No.	Date	ADDENDUM #3	Item
3	9/24/25	ADDENDUM #3	

DESIGN	ALN
DRAWN	TRS
CHECKED	LAR
DATE	04-16-2025

PROJECT No.

10297.24002

SHEET NUMBER

D-111

SHEET TITLE :

SITE PLAN - PROCESS

PROJECT :

CITY & BOROUGH OF YAKUTAT

WATER SYSTEM EXTENSION

YAKUTAT, ALASKA

Juneau, AK

9103 Mendenhall Mall Rd, Ste 4

Juneau, AK 99801

Phone: 907.780.0360

www.respec.com

AECOC 63270

RESPEC



CONSULTANT :