
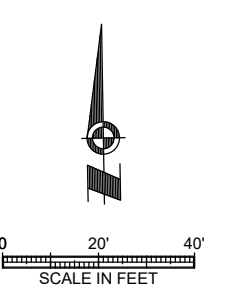


1" IF THIS BAR DOES NOT MEASURE EXACTLY ONE INCH, THE SCALE OF THIS DRAWING HAS BEEN ALTERED DURING IT'S PRODUCTION, AFFECTING ALL LABELED SCALES

N:\Projects\10297.24002\CSV_Airport_Wtr_Ext\Volume 2_Pump House\10297.24002-C-SITE SITE PLAN Apr 18, 2025 9:12 AM

C-101 SITE PLAN				
POINT #	NORTHING	EASTING	ELEVATION	DESCRIPTION
101	2865390.48	1563235.01	39.25	EG COR
102	2865280.64	1563265.20	39.25	EG COR
103	2865353.21	1563313.66	40.00	CNTR TANK
104	2865392.75	1563380.85	40.00	BLDG COR / FG
105	2865354.23	1563391.62	40.00	BLDG COR / FG
106	2865435.54	1563396.93	39.33	EG COR
107	2865325.68	1563427.43	39.33	EG COR
108	2865297.99	1563327.67	39.51	EG
109	2865383.33	1563347.14	40.00	BLDG COR / FG
110	2865473.34	1563293.94	38.57	PT EG
111	2865497.70	1563366.94	37.60	PT EG
112	2865452.82	1563330.89	38.96	PC EG
113	2865461.47	1563349.21	38.49	PC EG
114	2865425.19	1563359.73	39.50	EG COR
115	2865419.83	1563340.46	39.50	EG COR
116	2865405.16	1563287.73	39.47	EG
117	2865388.04	1563364.00	40.22	EG

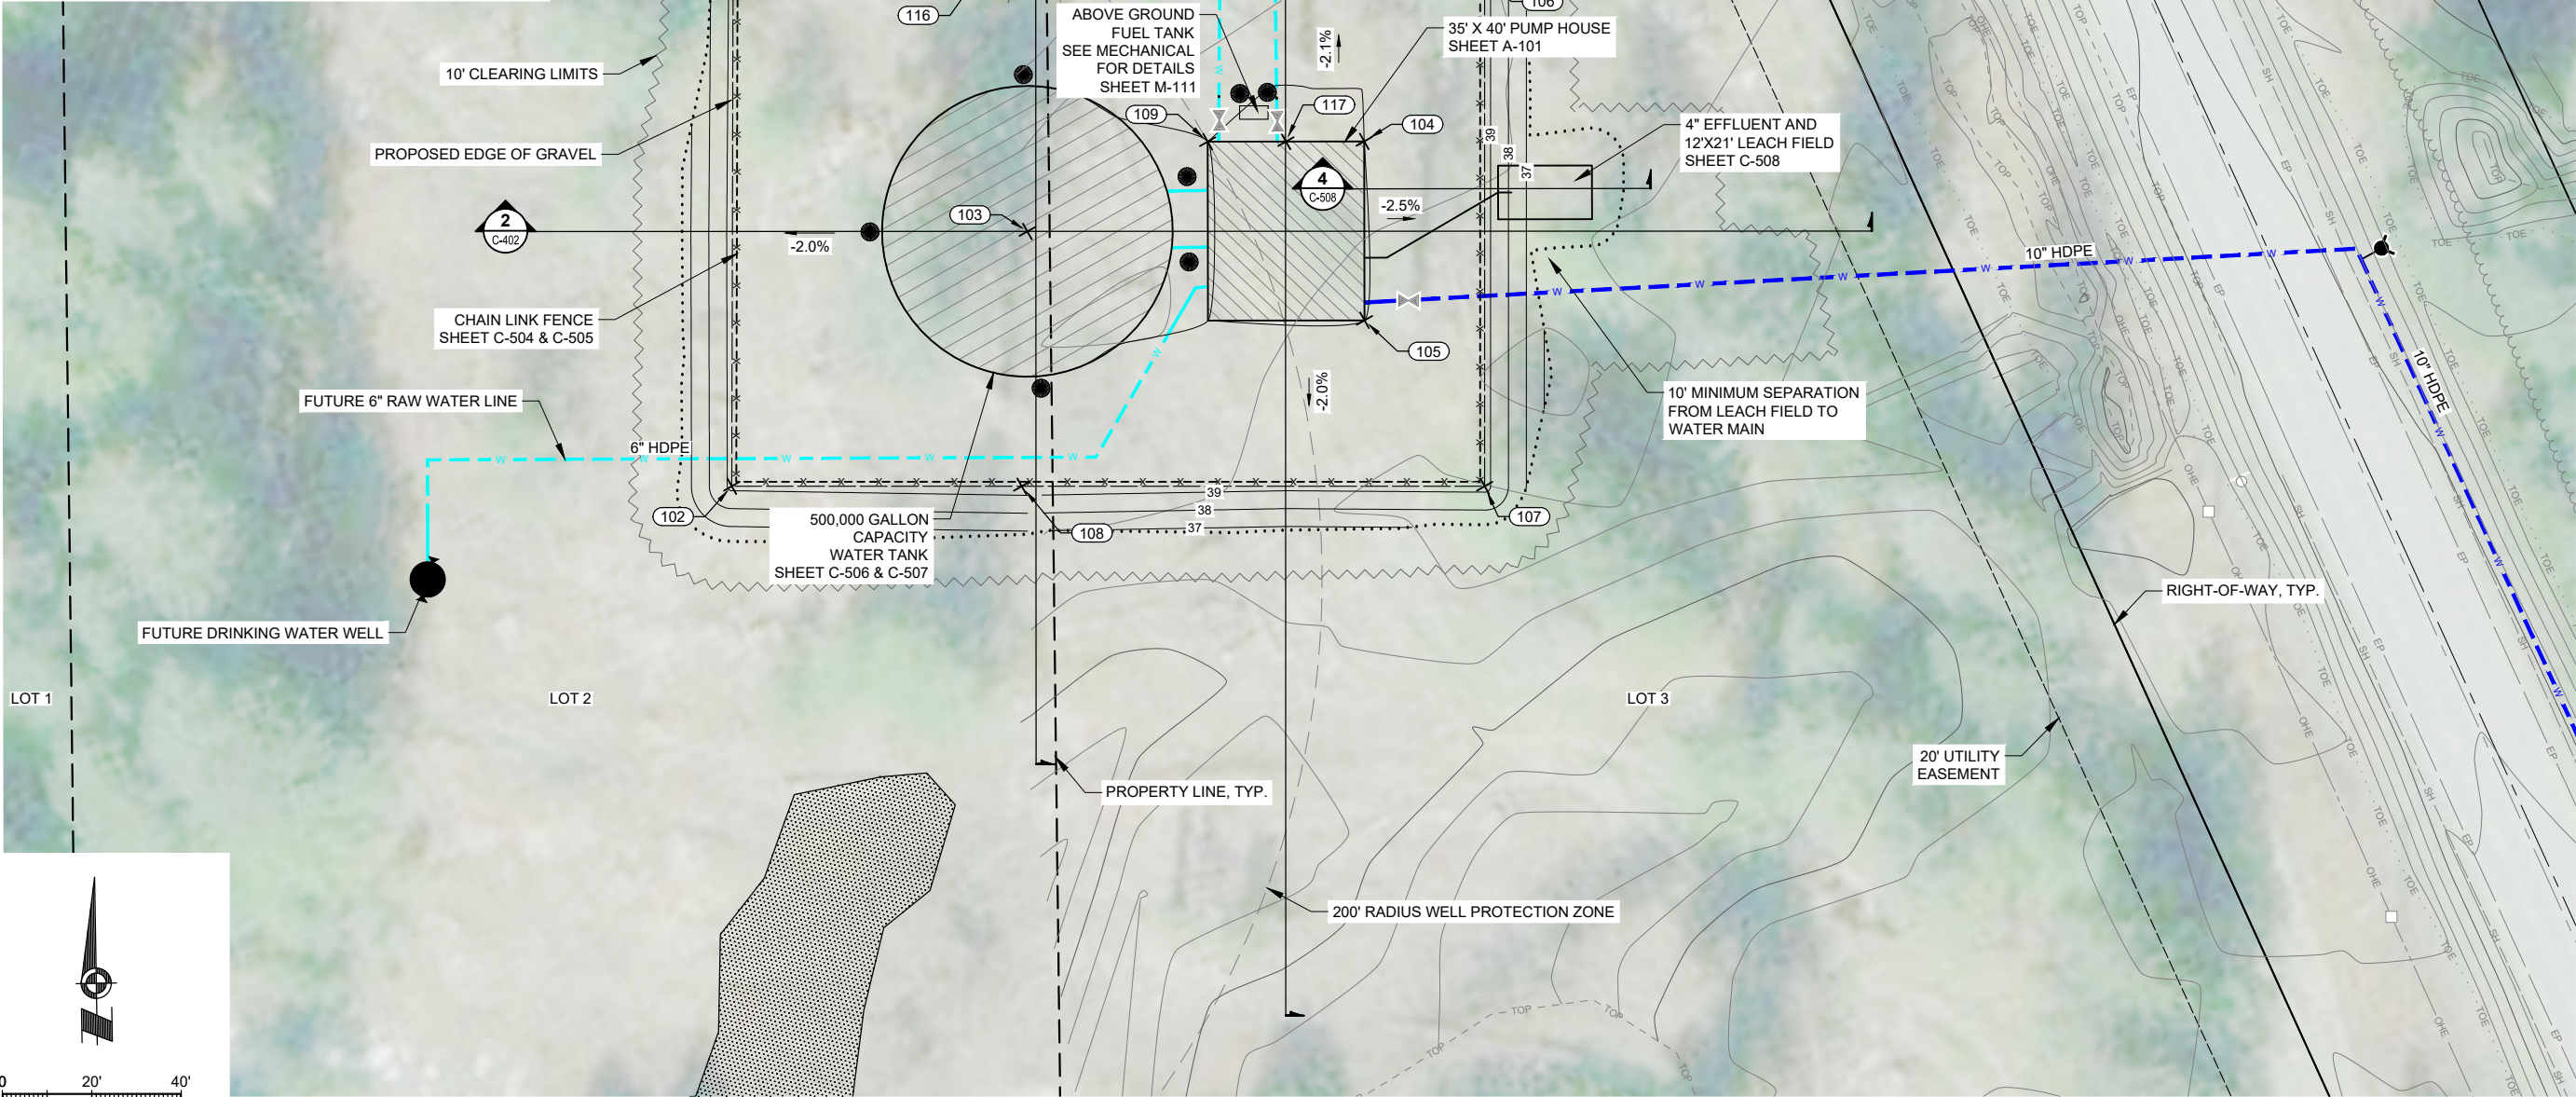

CONSULTANT :

STATE OF ALASKA
49TH
KAREN ANN BRADY
04/16/2025
CE 11523
REGISTERED PROFESSIONAL ENGINEER

Juneau, AK
9009 Mendota Hall Rd. Ste. 4
Juneau, AK 99801
Phone: 907.586.3771
Fax: 907.586.3771
AEC 163270

PROJECT :

CITY & BOROUGH OF YAKUTAT
WATER SYSTEM EXTENSION

YAKUTAT, ALASKA

SHEET TITLE :

PUMP HOUSE SITE PLAN

DESIGN

AMN

DRAWN

HRB

CHECKED

KAB

DATE

04-16-2025

PROJECT No.

10297.24002

SHEET NUMBER

C-101