
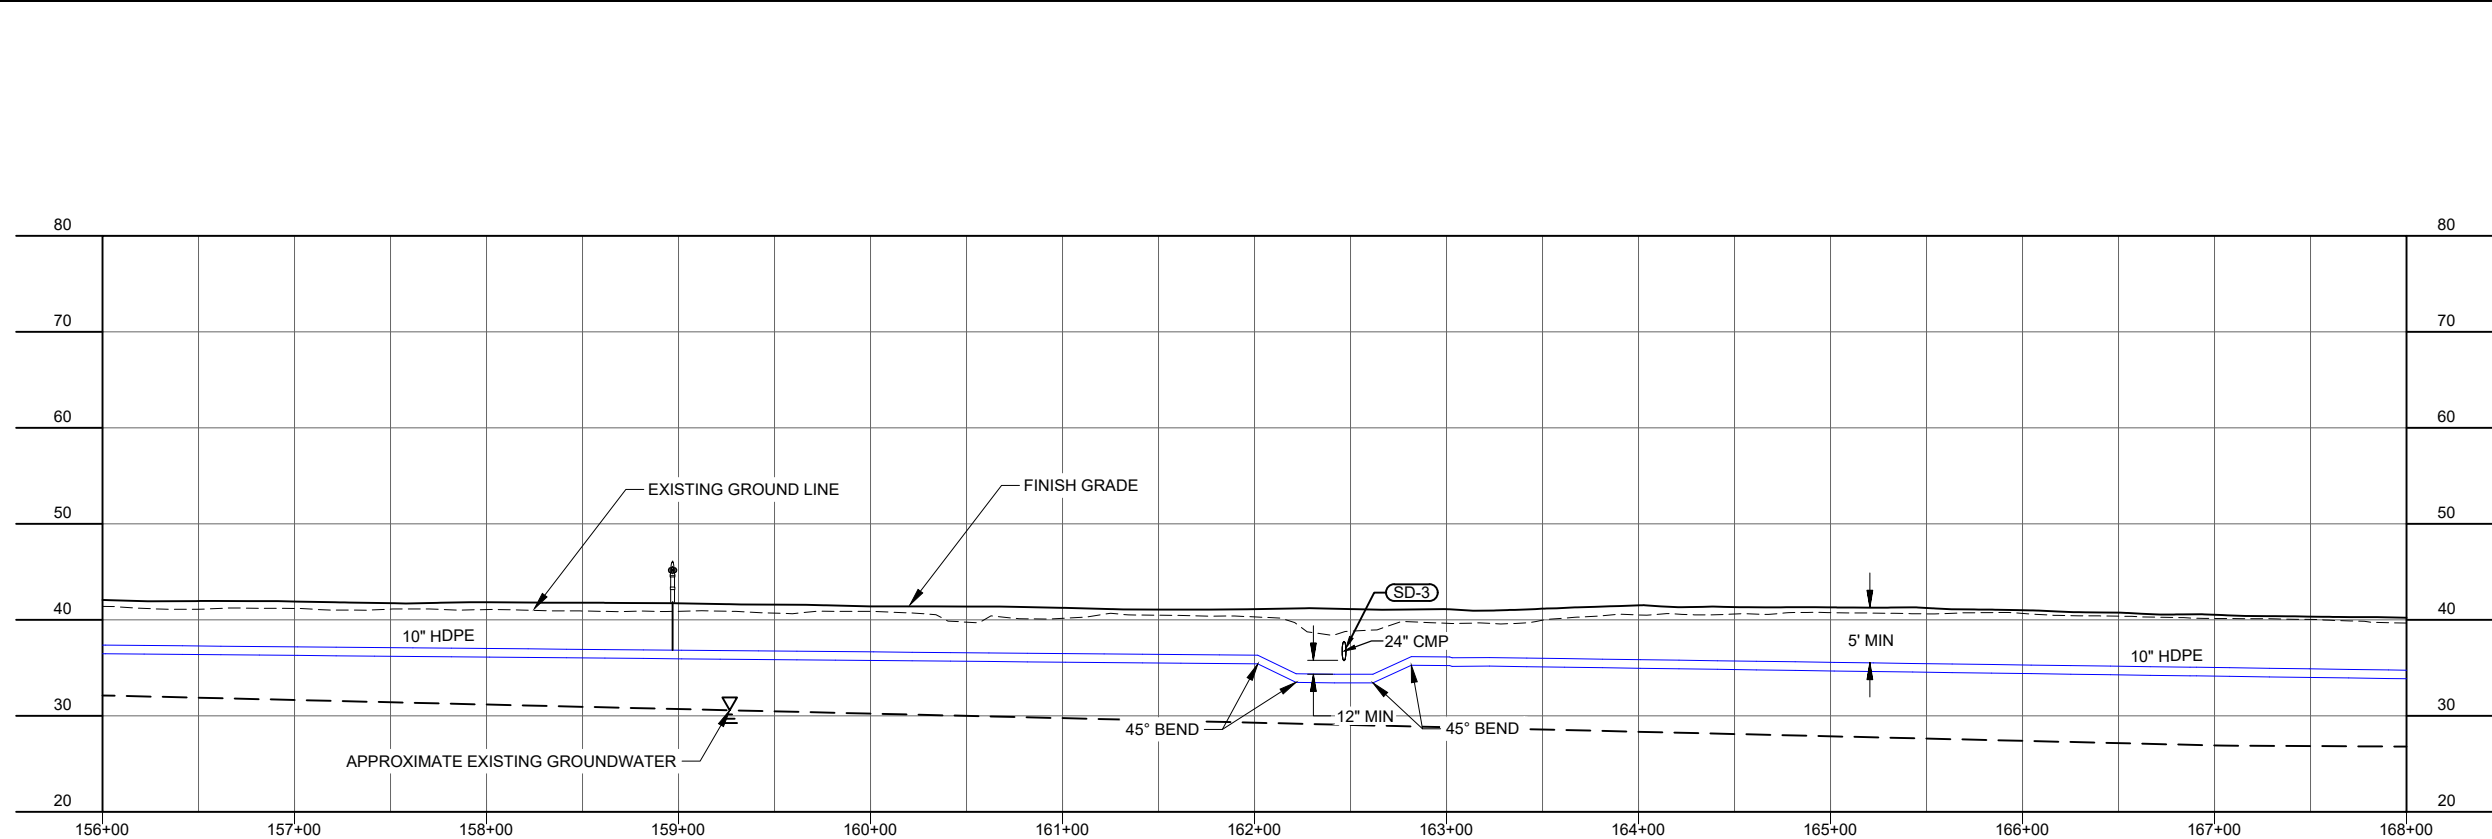


1" IF THIS BAR DOES NOT MEASURE EXACTLY ONE INCH, THE SCALE OF THIS DRAWING HAS BEEN ALTERED DURING ITS PRODUCTION, AFFECTING ALL LABELED SCALES

N:\Projects\10297.24002\City_Airport_Wtr_Ext\10297.24002-C-PlanProfile\10297.24002-C-314.dwg, 04/16/2025, 9:16 AM

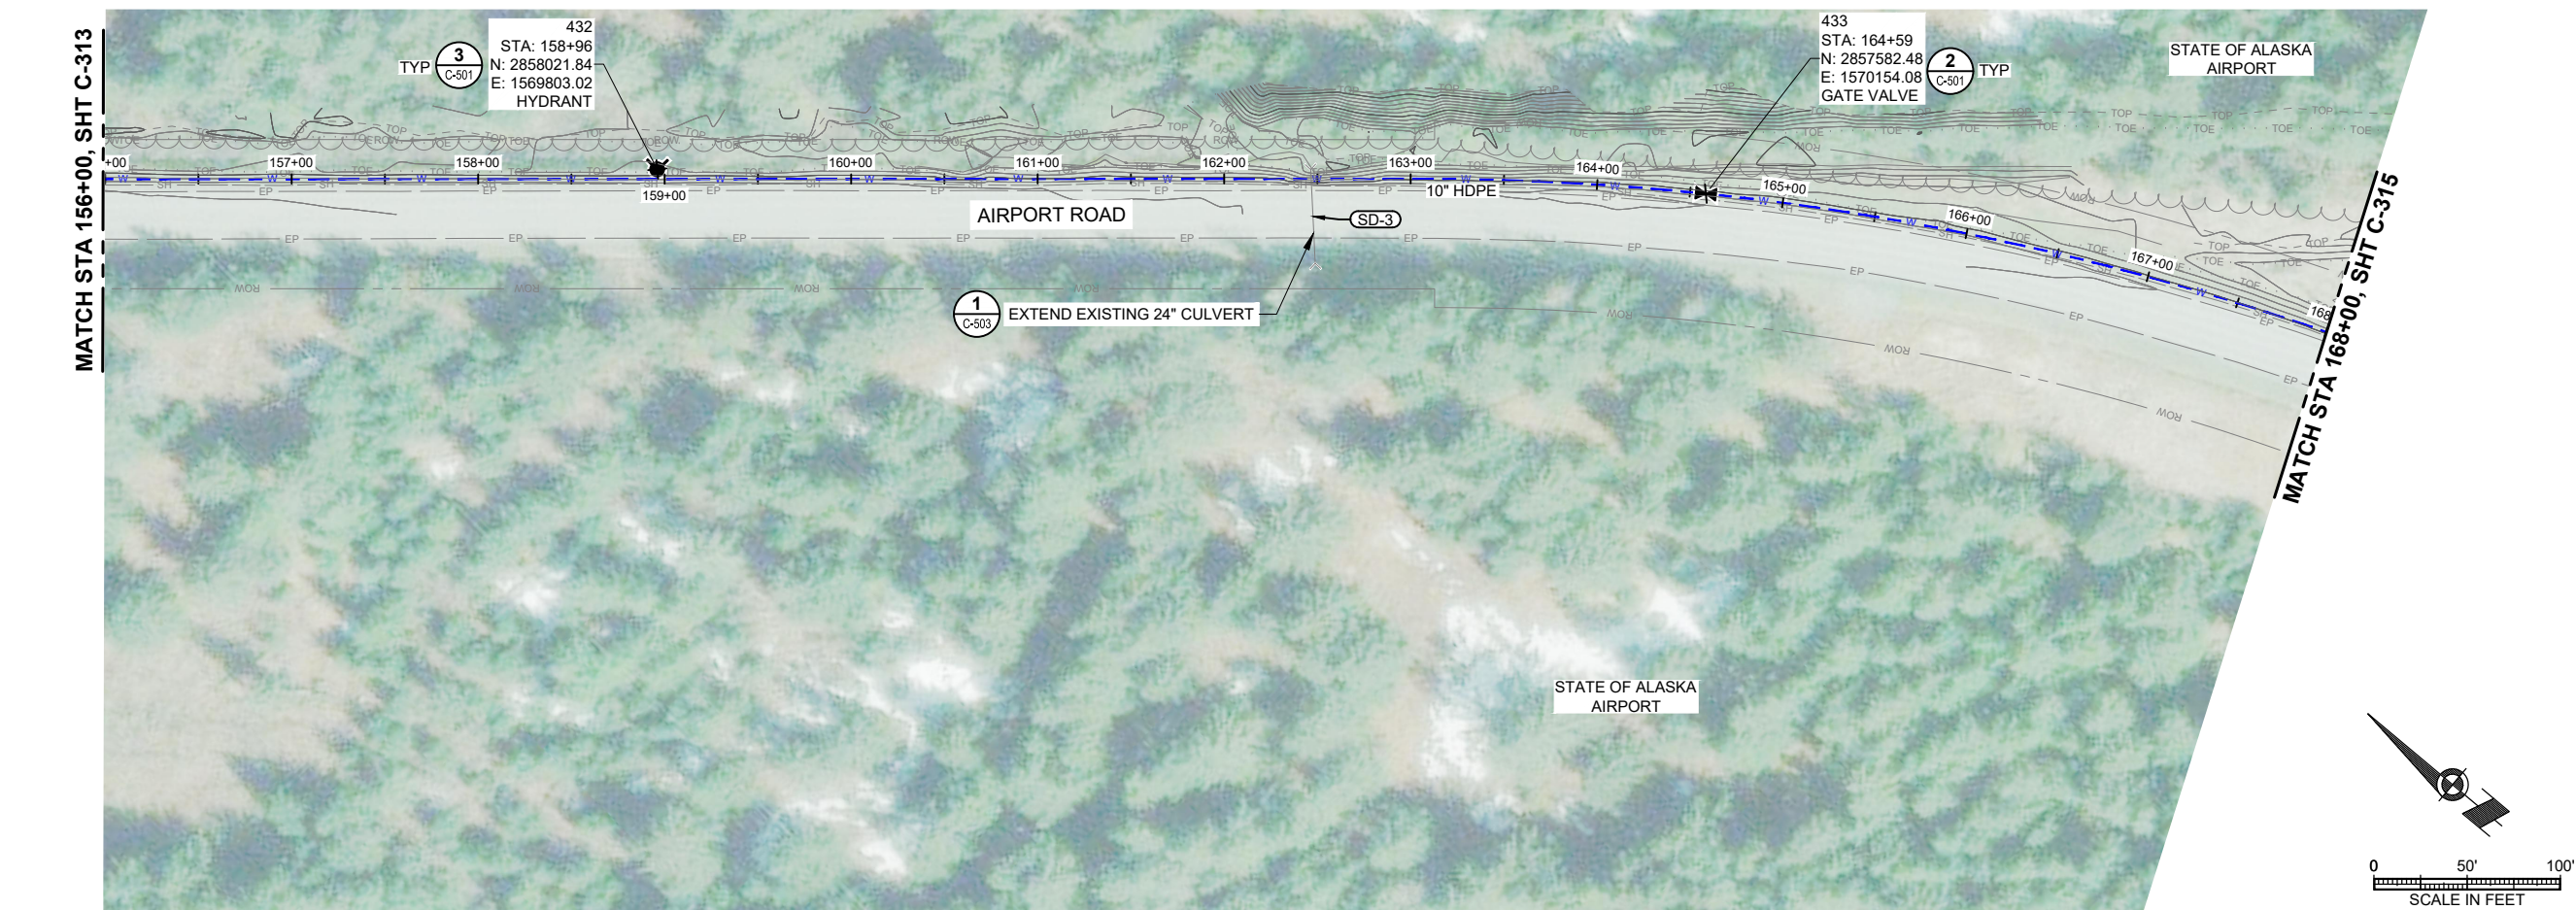

CONSULTANT :

STATE OF ALASKA
49 TH
KAREN ANN BRADY
04/16/2025
CE 11523
REGISTERED PROFESSIONAL ENGINEER

Juneau, AK
9100 Mendota Mall Rd. Ste. 4
Juneau, AK 99801
Phone: 907.586.3771
Fax: 907.586.3771
AEC0163270

PROJECT :
CITY & BOROUGH OF YAKUTAT
WATER SYSTEM EXTENSION
YAKUTAT, ALASKA

SHEET TITLE :
PLAN AND PROFILE -
AIRPORT ROAD (11 OF 14)

DESIGN	AMN
DRAWN	HRB
CHECKED	KAB
DATE	04-16-2025

PROJECT No.
10297.24002

SHEET NUMBER
C-314