


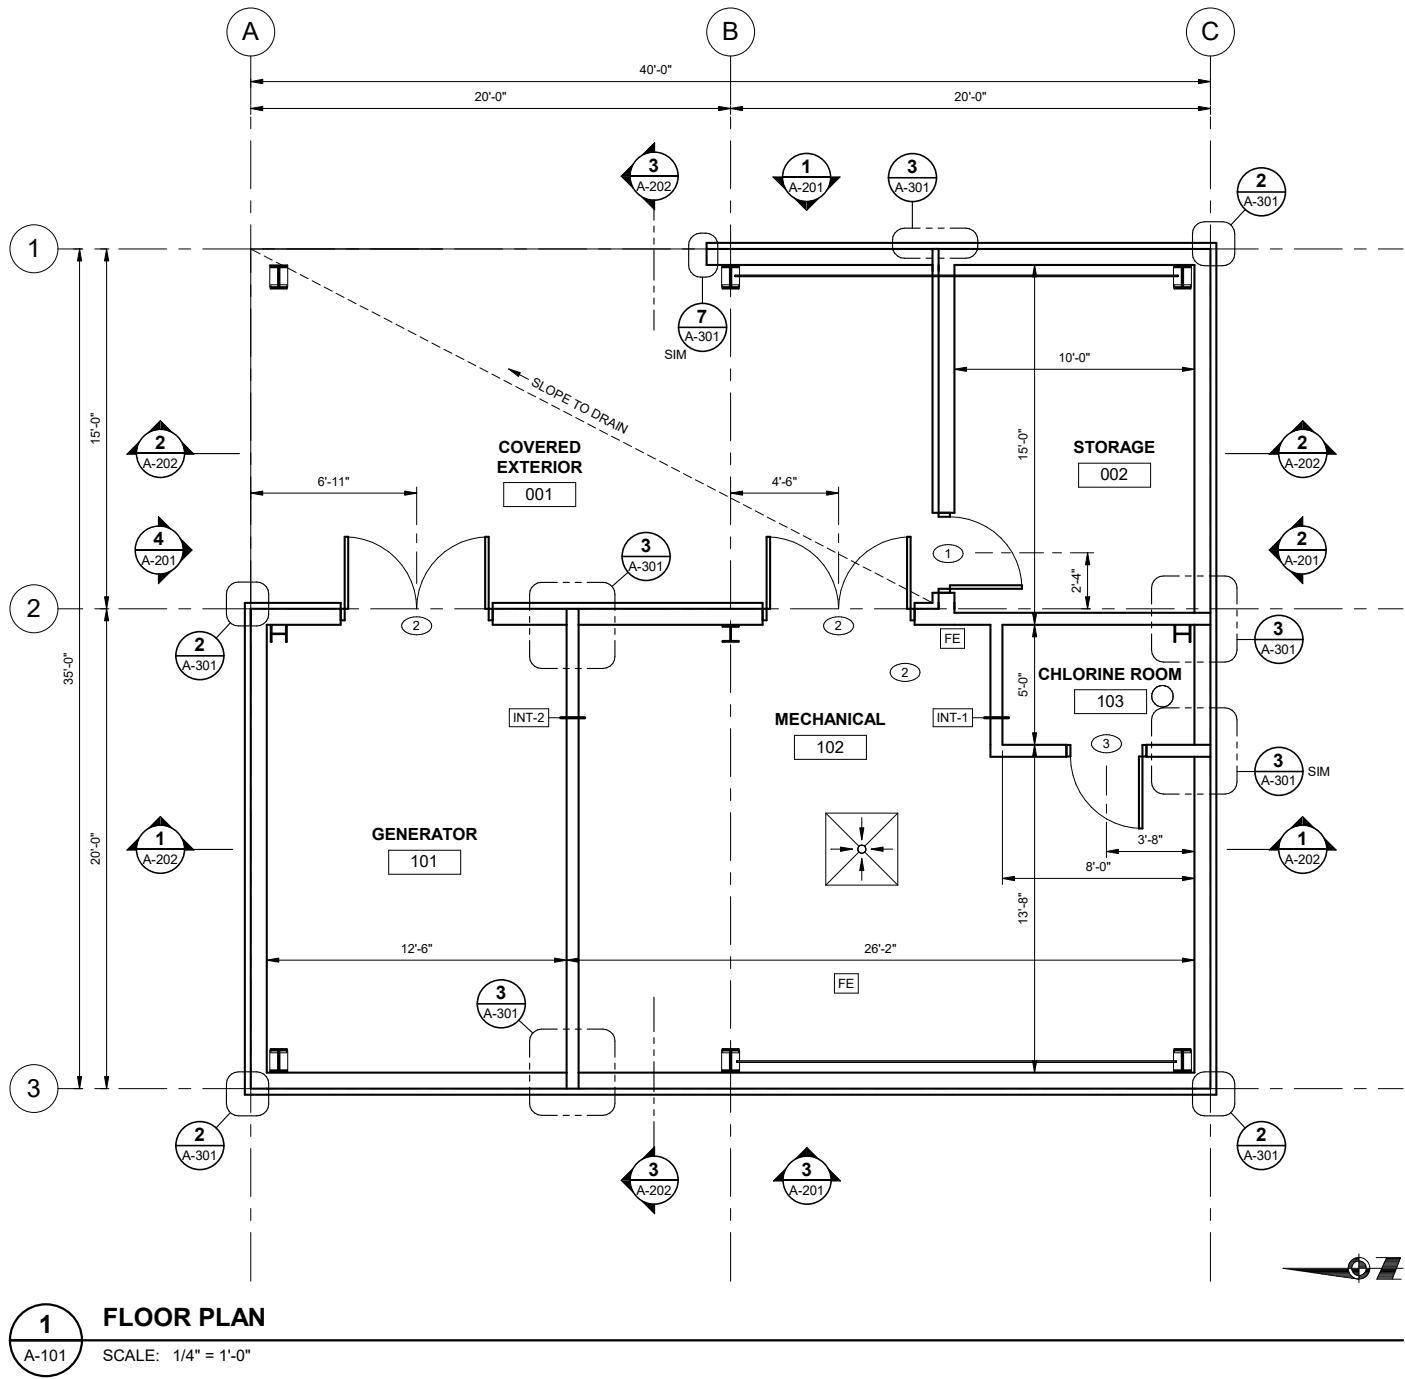

SHEET NOTES

- ALL NEW CONSTRUCTION DIMENSIONS ARE TO FACE OF FRAMING UNLESS NOTED OTHERWISE.
- ALL DIMENSIONS INDICATED AS CLEAR SHALL PROVIDE CLEARANCE TO FACE OF FINISH.
- INTERIOR DOORS TO BE LOCATED 4" CLEAR FROM FACE OF ADJACENT FRAMING, OR AS DIMENSIONED.
- SEE E-111 FOR REFLECTED CEILING PLAN (OPEN TO STRUCTURE).
- REFER TO MECHANICAL, ELECTRICAL, AND FIRE PROTECTION PLANS FOR EQUIPMENT AND RELATED ASSEMBLIES. CONTRACTOR TO COORDINATE WORK WITH OTHER TRADES.
- OPENINGS ARE DIMENSIONED TO CENTER OF OPENING. REFER TO DOOR SCHEDULE.
- SEE STRUCTURAL FOR HEADER SIZE AS REQUIRED.
- PROVIDE RATED PENETRATION ASSEMBLIES THROUGH RATED WALLS.

CONSULTANT :

STATE OF ALASKA

49<sup>TH</sup>

Trent Mullins

TRENT K MULLINS

No. AEA11194

4/16/25

REGISTERED PROFESSIONAL ARCHITECT

Juneau, AK

9103 Mendernall Mall Rd. Ste 4

Juneau, AK 99801

Phone: 907.780.6060

www.respec.com

AEC0163270

RESPEC

PROJECT :

CITY & BOROUGH OF YAKUTAT

WATER SYSTEM EXTENSION

YAKUTAT, ALASKA

SHEET TITLE :

PUMP HOUSE FLOOR PLAN

|         |            |
|---------|------------|
| DESIGN  | TKM        |
| DRAWN   | DJM        |
| CHECKED | TKM        |
| DATE    | 04-16-2025 |

PROJECT No.  
10297.24002  
SHEET NUMBER

A-101

| No.       | Date | Item |
|-----------|------|------|
| REVISIONS |      |      |