
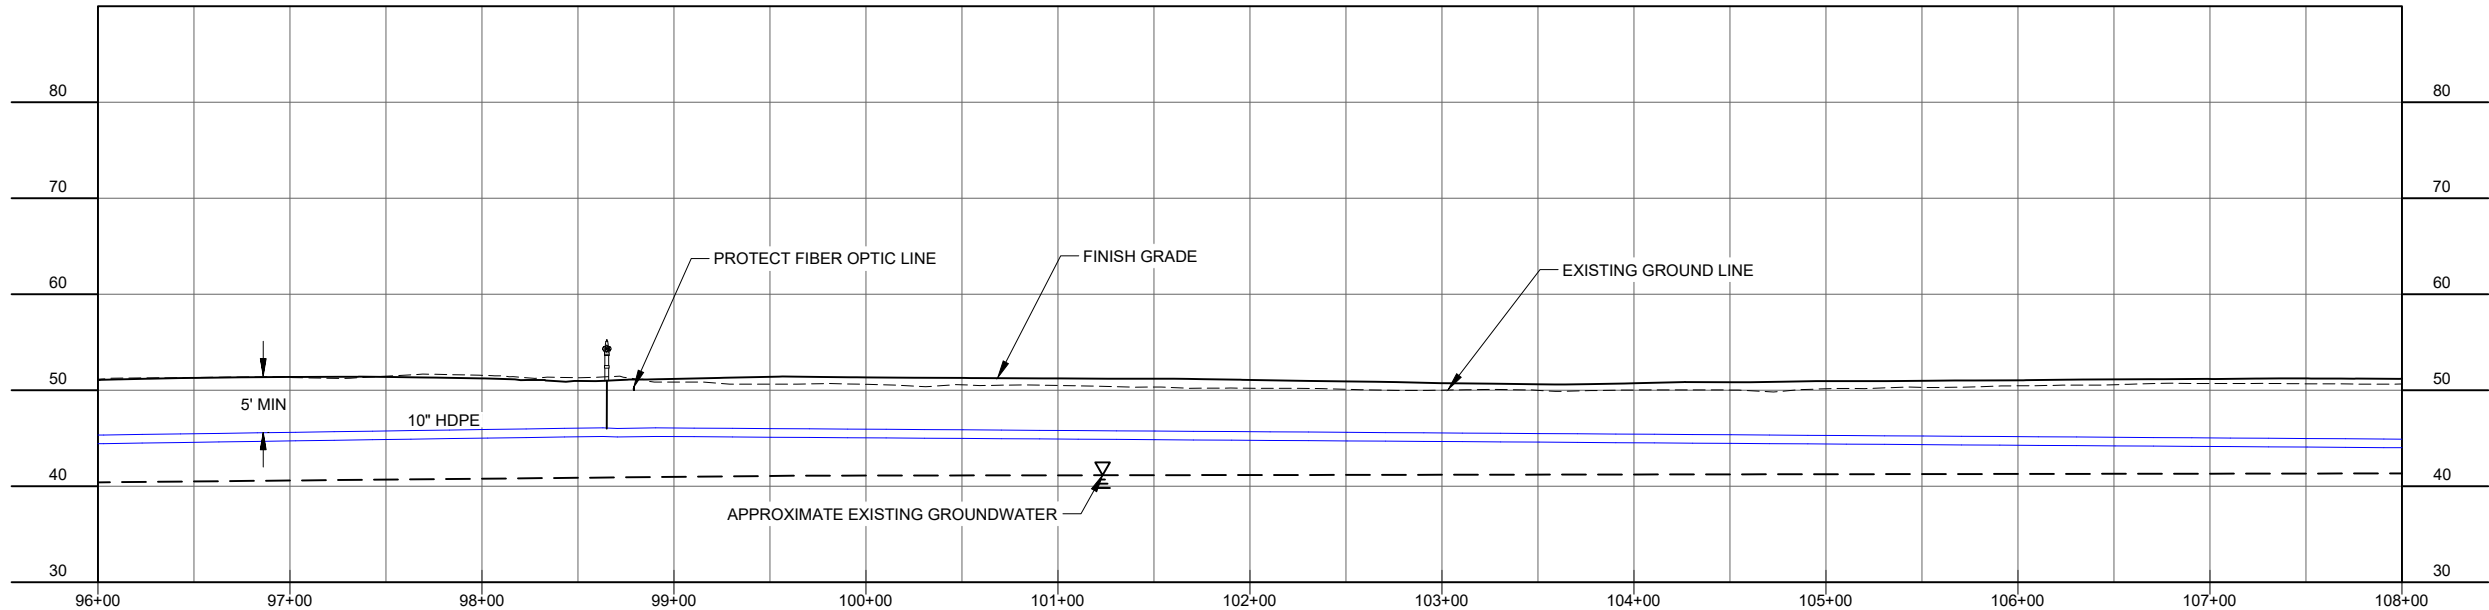


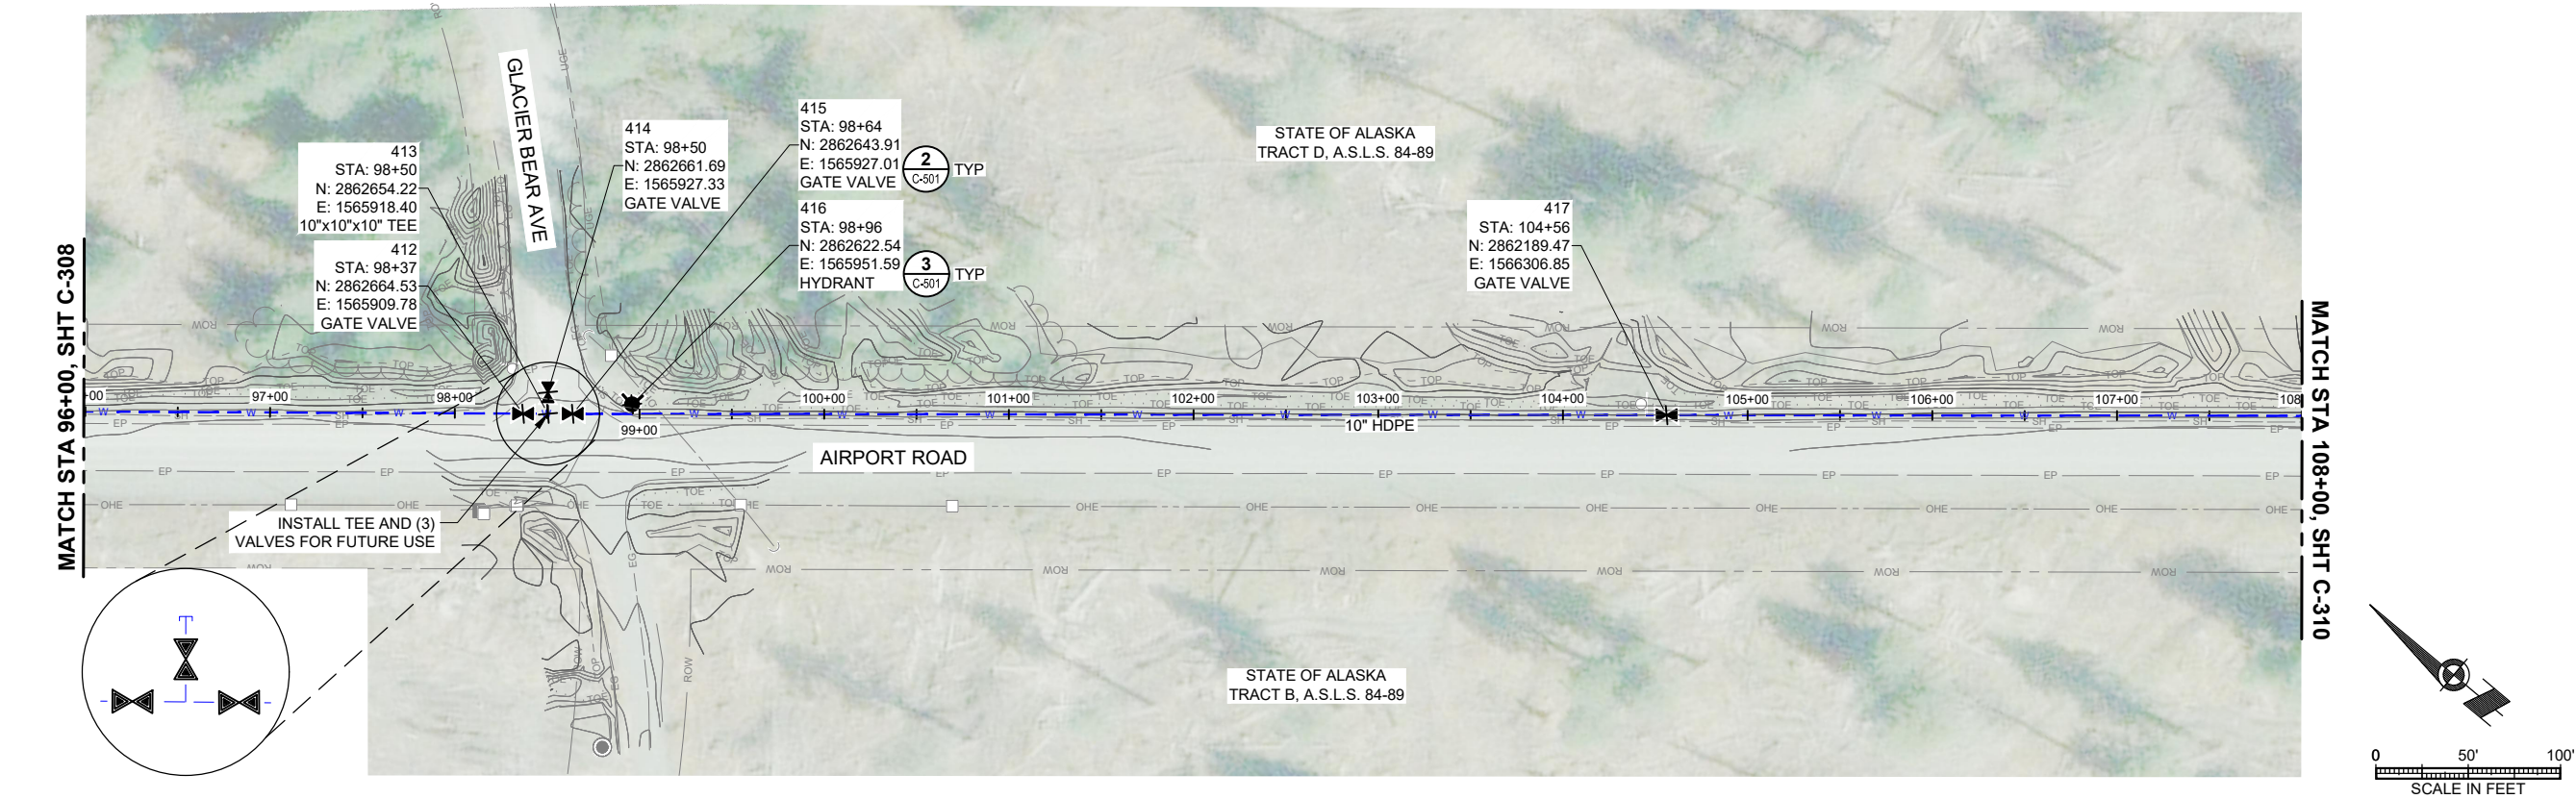

CONSULTANT :

STATE OF ALASKA
10297.24002
49 TH
Karen Ann Brady
KAREN ANN BRADY
04/16/2025
CE 11523
REGISTERED PROFESSIONAL ENGINEER

Juneau, AK
9000 Mendota Mall Rd. Ste. 4
Juneau, AK 99801
Phone: 907.586.3771
Fax: 907.586.3771
AECOC 63270

PROJECT :

CITY & BOROUGH OF YAKUTAT
WATER SYSTEM EXTENSION
YAKUTAT, ALASKA

SHEET TITLE :

PLAN AND PROFILE -
AIRPORT ROAD (6 OF 14)

DESIGN

AMN

DRAWN

HRB

CHECKED

KAB

DATE

04-16-2025

PROJECT No.

10297.24002

SHEET NUMBER

C-309