
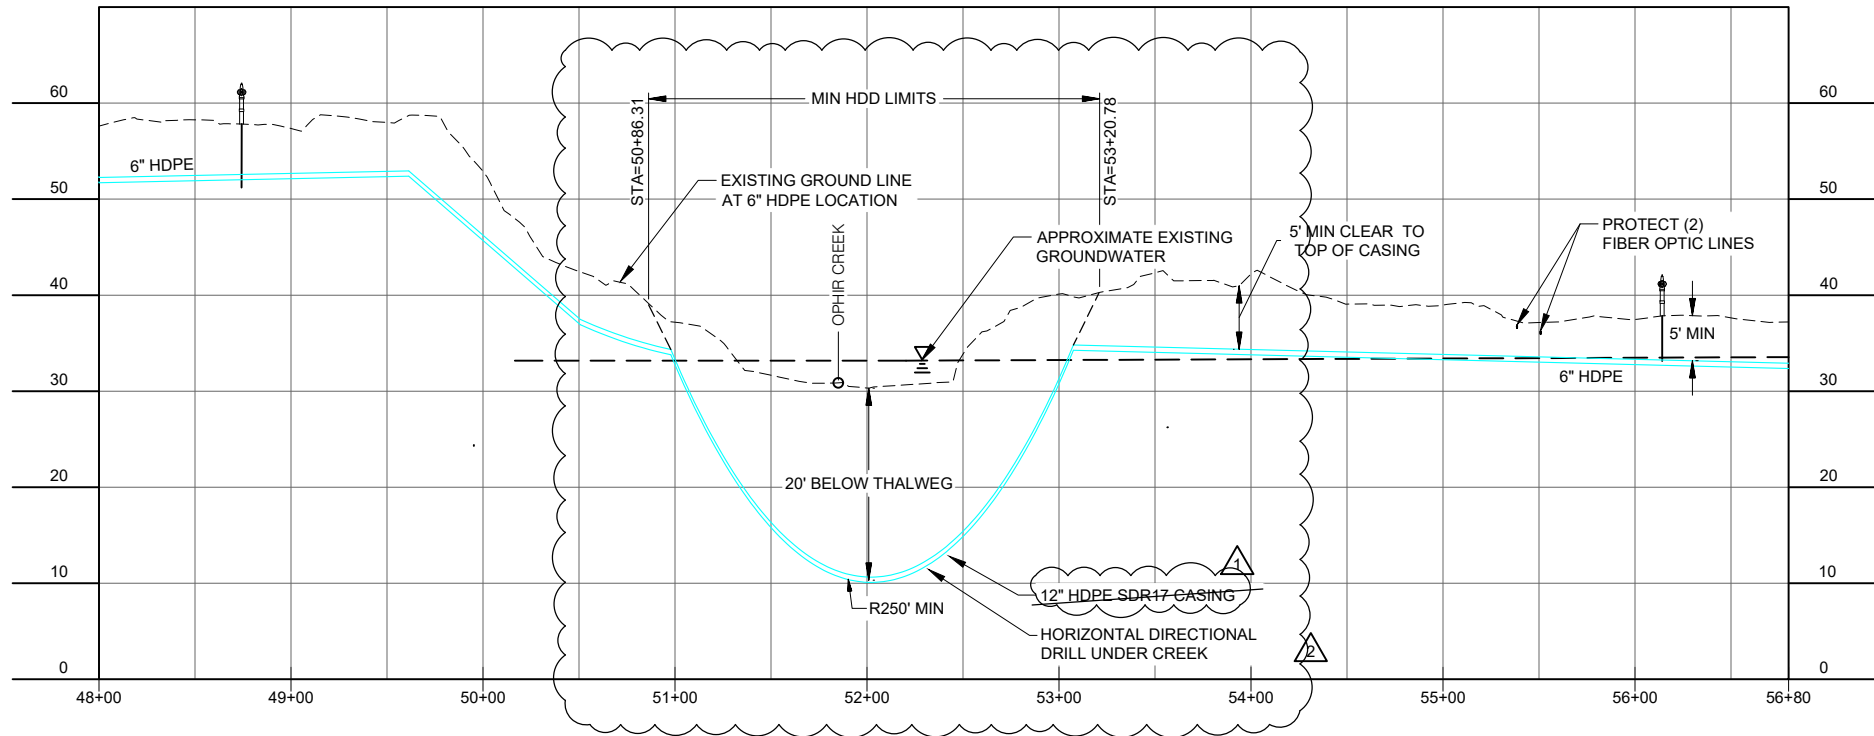


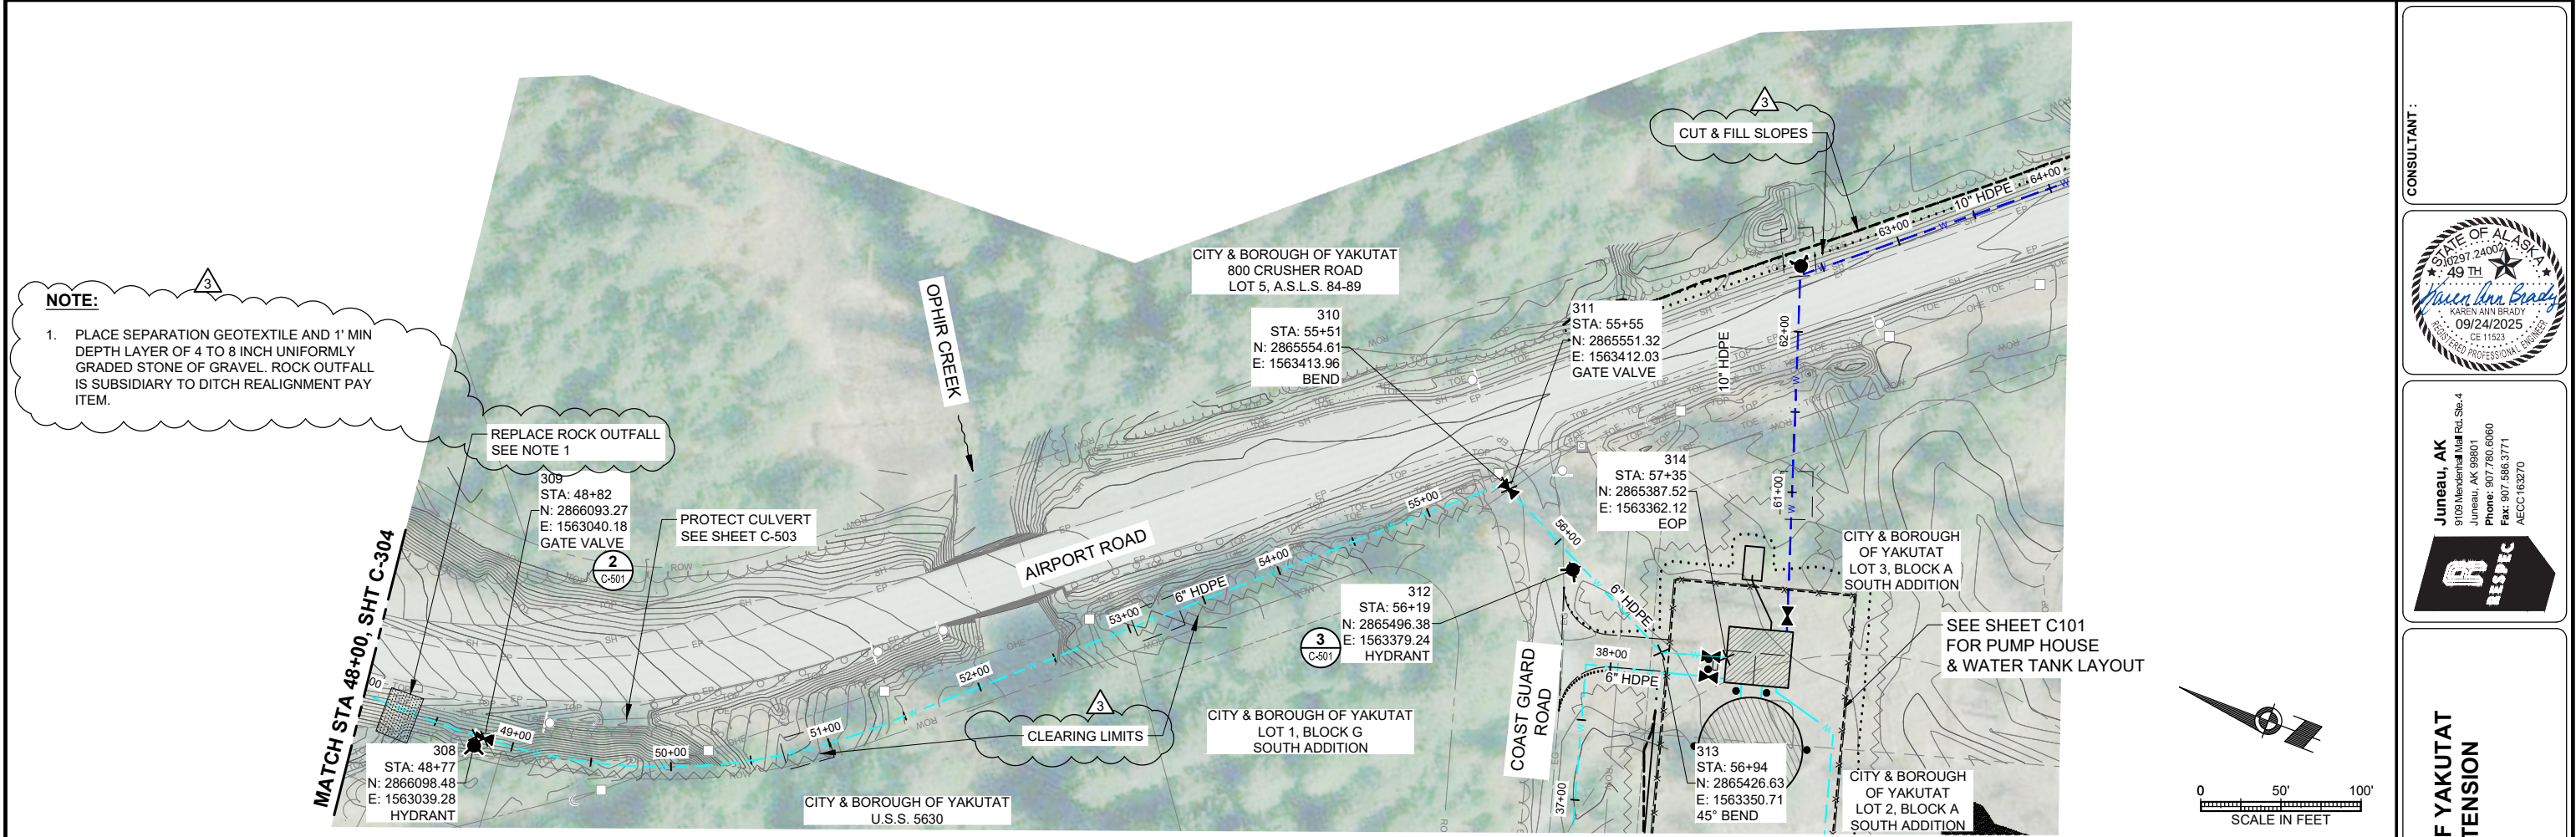

						DRAWN	HRB
						CHECKED	KAB
						DATE	04-16-2025
						PROJECT No. 10297.24002	
						SHEET NUMBER	
						C-305	

CONSULTANT :

STATE OF ALASKA
49 TH
KAREN ANN BRADY
09/24/2025
09/11/23
REGISTERED PROFESSIONAL ENGINEER

Juneau, AK
9100 Mendenhall Rd. Ste. 4
Juneau, AK 99801
Phone: 907.586.6060
Fax: 907.586.3771
AEC 163270

PROJECT :

CITY & BOROUGH OF YAKUTAT
WATER SYSTEM EXTENSION

YAKUTAT, ALASKA

SHEET TITLE :

PLAN AND PROFILE -
AIRPORT ROAD (2 OF 14)