
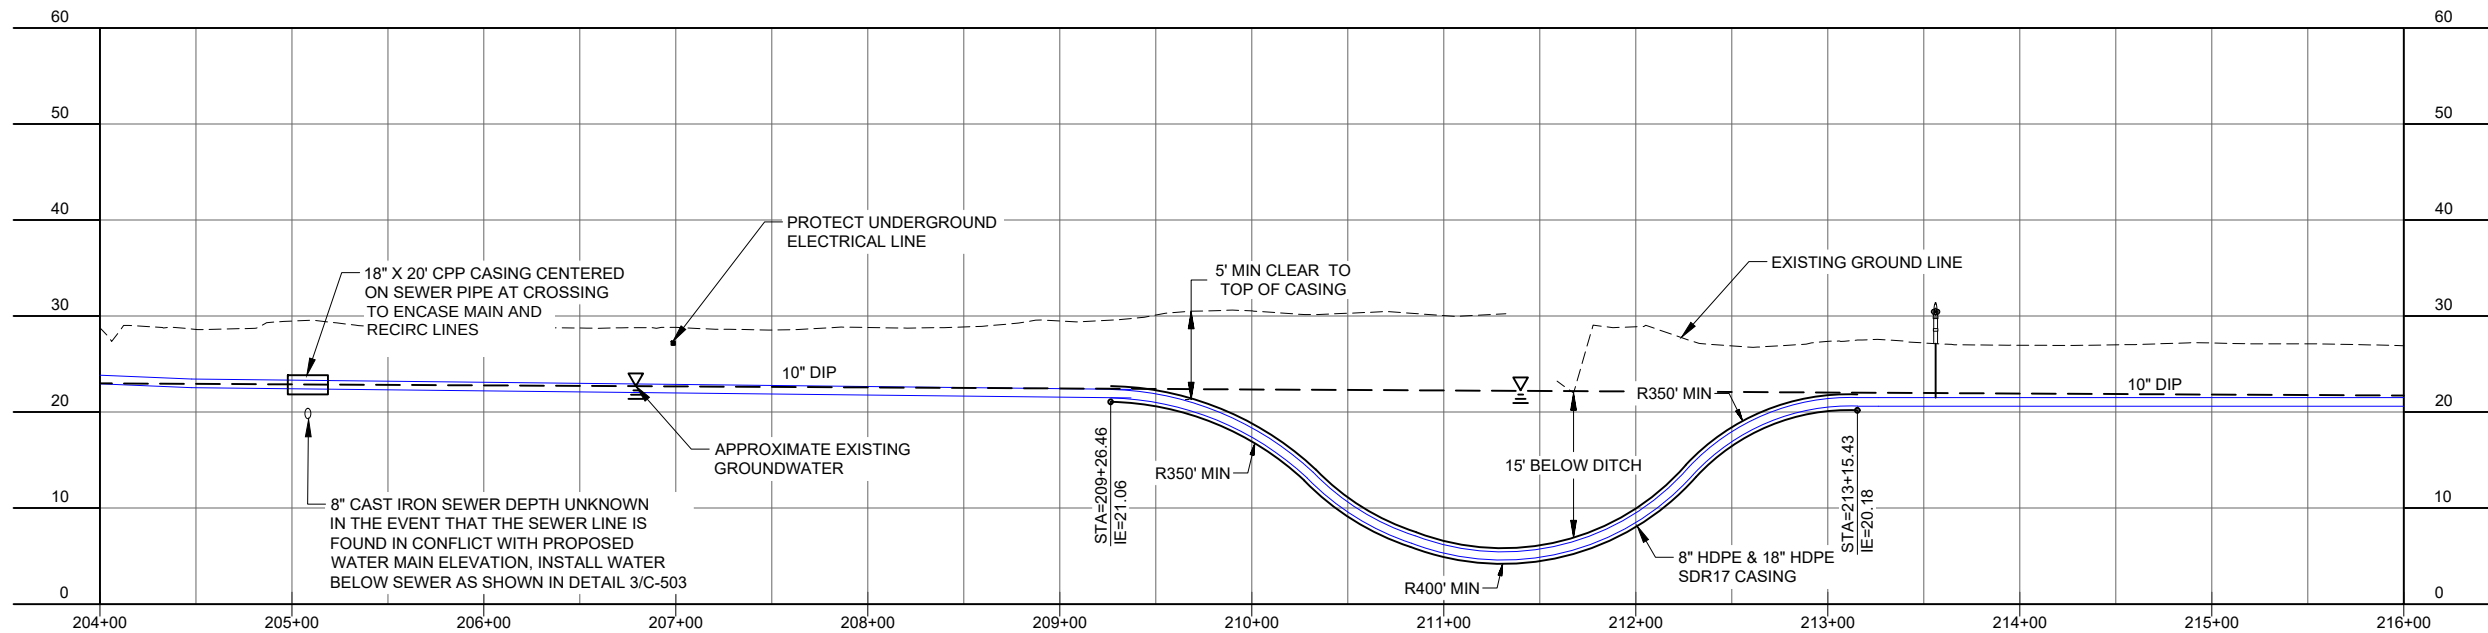


1" IF THIS BAR DOES NOT MEASURE EXACTLY ONE INCH, THE SCALE OF THIS DRAWING HAS BEEN ALTERED DURING ITS PRODUCTION, AFFECTING ALL LABELED SCALES

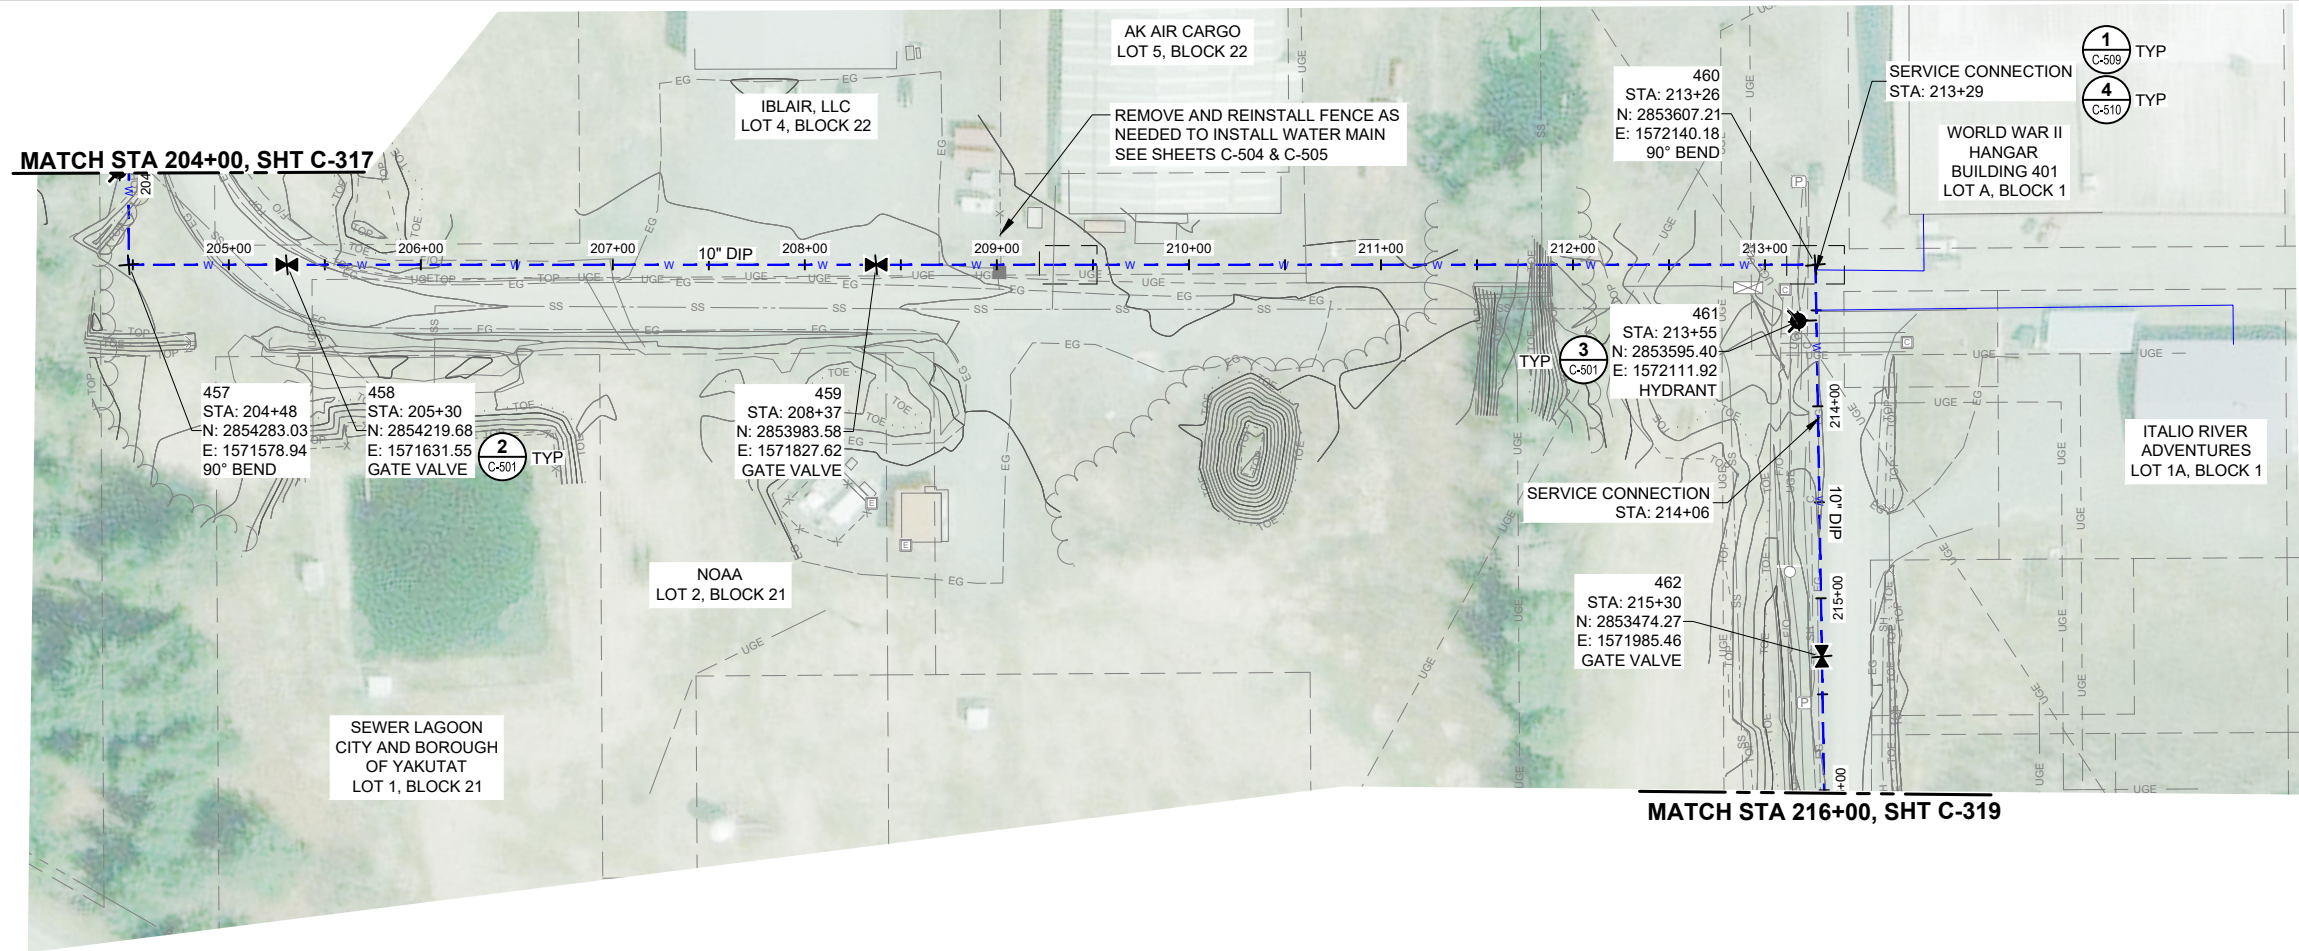

CONSULTANT :

STATE OF ALASKA
49TH
KAREN ANN BRADY
04/16/2025
REGISTERED PROFESSIONAL ENGINEER

Juneau, AK
9080 Mendota Rd. Ste. 4
Juneau, AK 99801
Phone: 907.586.3771
Fax: 907.586.3771
AECI 63270

PROJECT :
CITY & BOROUGH OF YAKUTAT
WATER SYSTEM EXTENSION

YAKUTAT, ALASKA

SHEET TITLE :
PLAN AND PROFILE -
AIRPORT AREA

DESIGN AMN
DRAWN HRB
CHECKED KAB
DATE 04-16-2025

PROJECT No.
10297.24002

SHEET NUMBER
C-318