


1" IF THIS BAR DOES NOT MEASURE EXACTLY ONE INCH, THE SCALE OF THIS DRAWING HAS BEEN ALTERED DURING ITS PRODUCTION, AFFECTING ALL LABELED SCALES

4/17/2025 10:58:10 AM AutodesK Docs//10297_24002-CBY Airport Water System Extension/INF-ELEC-10297_24002_RV23.v1

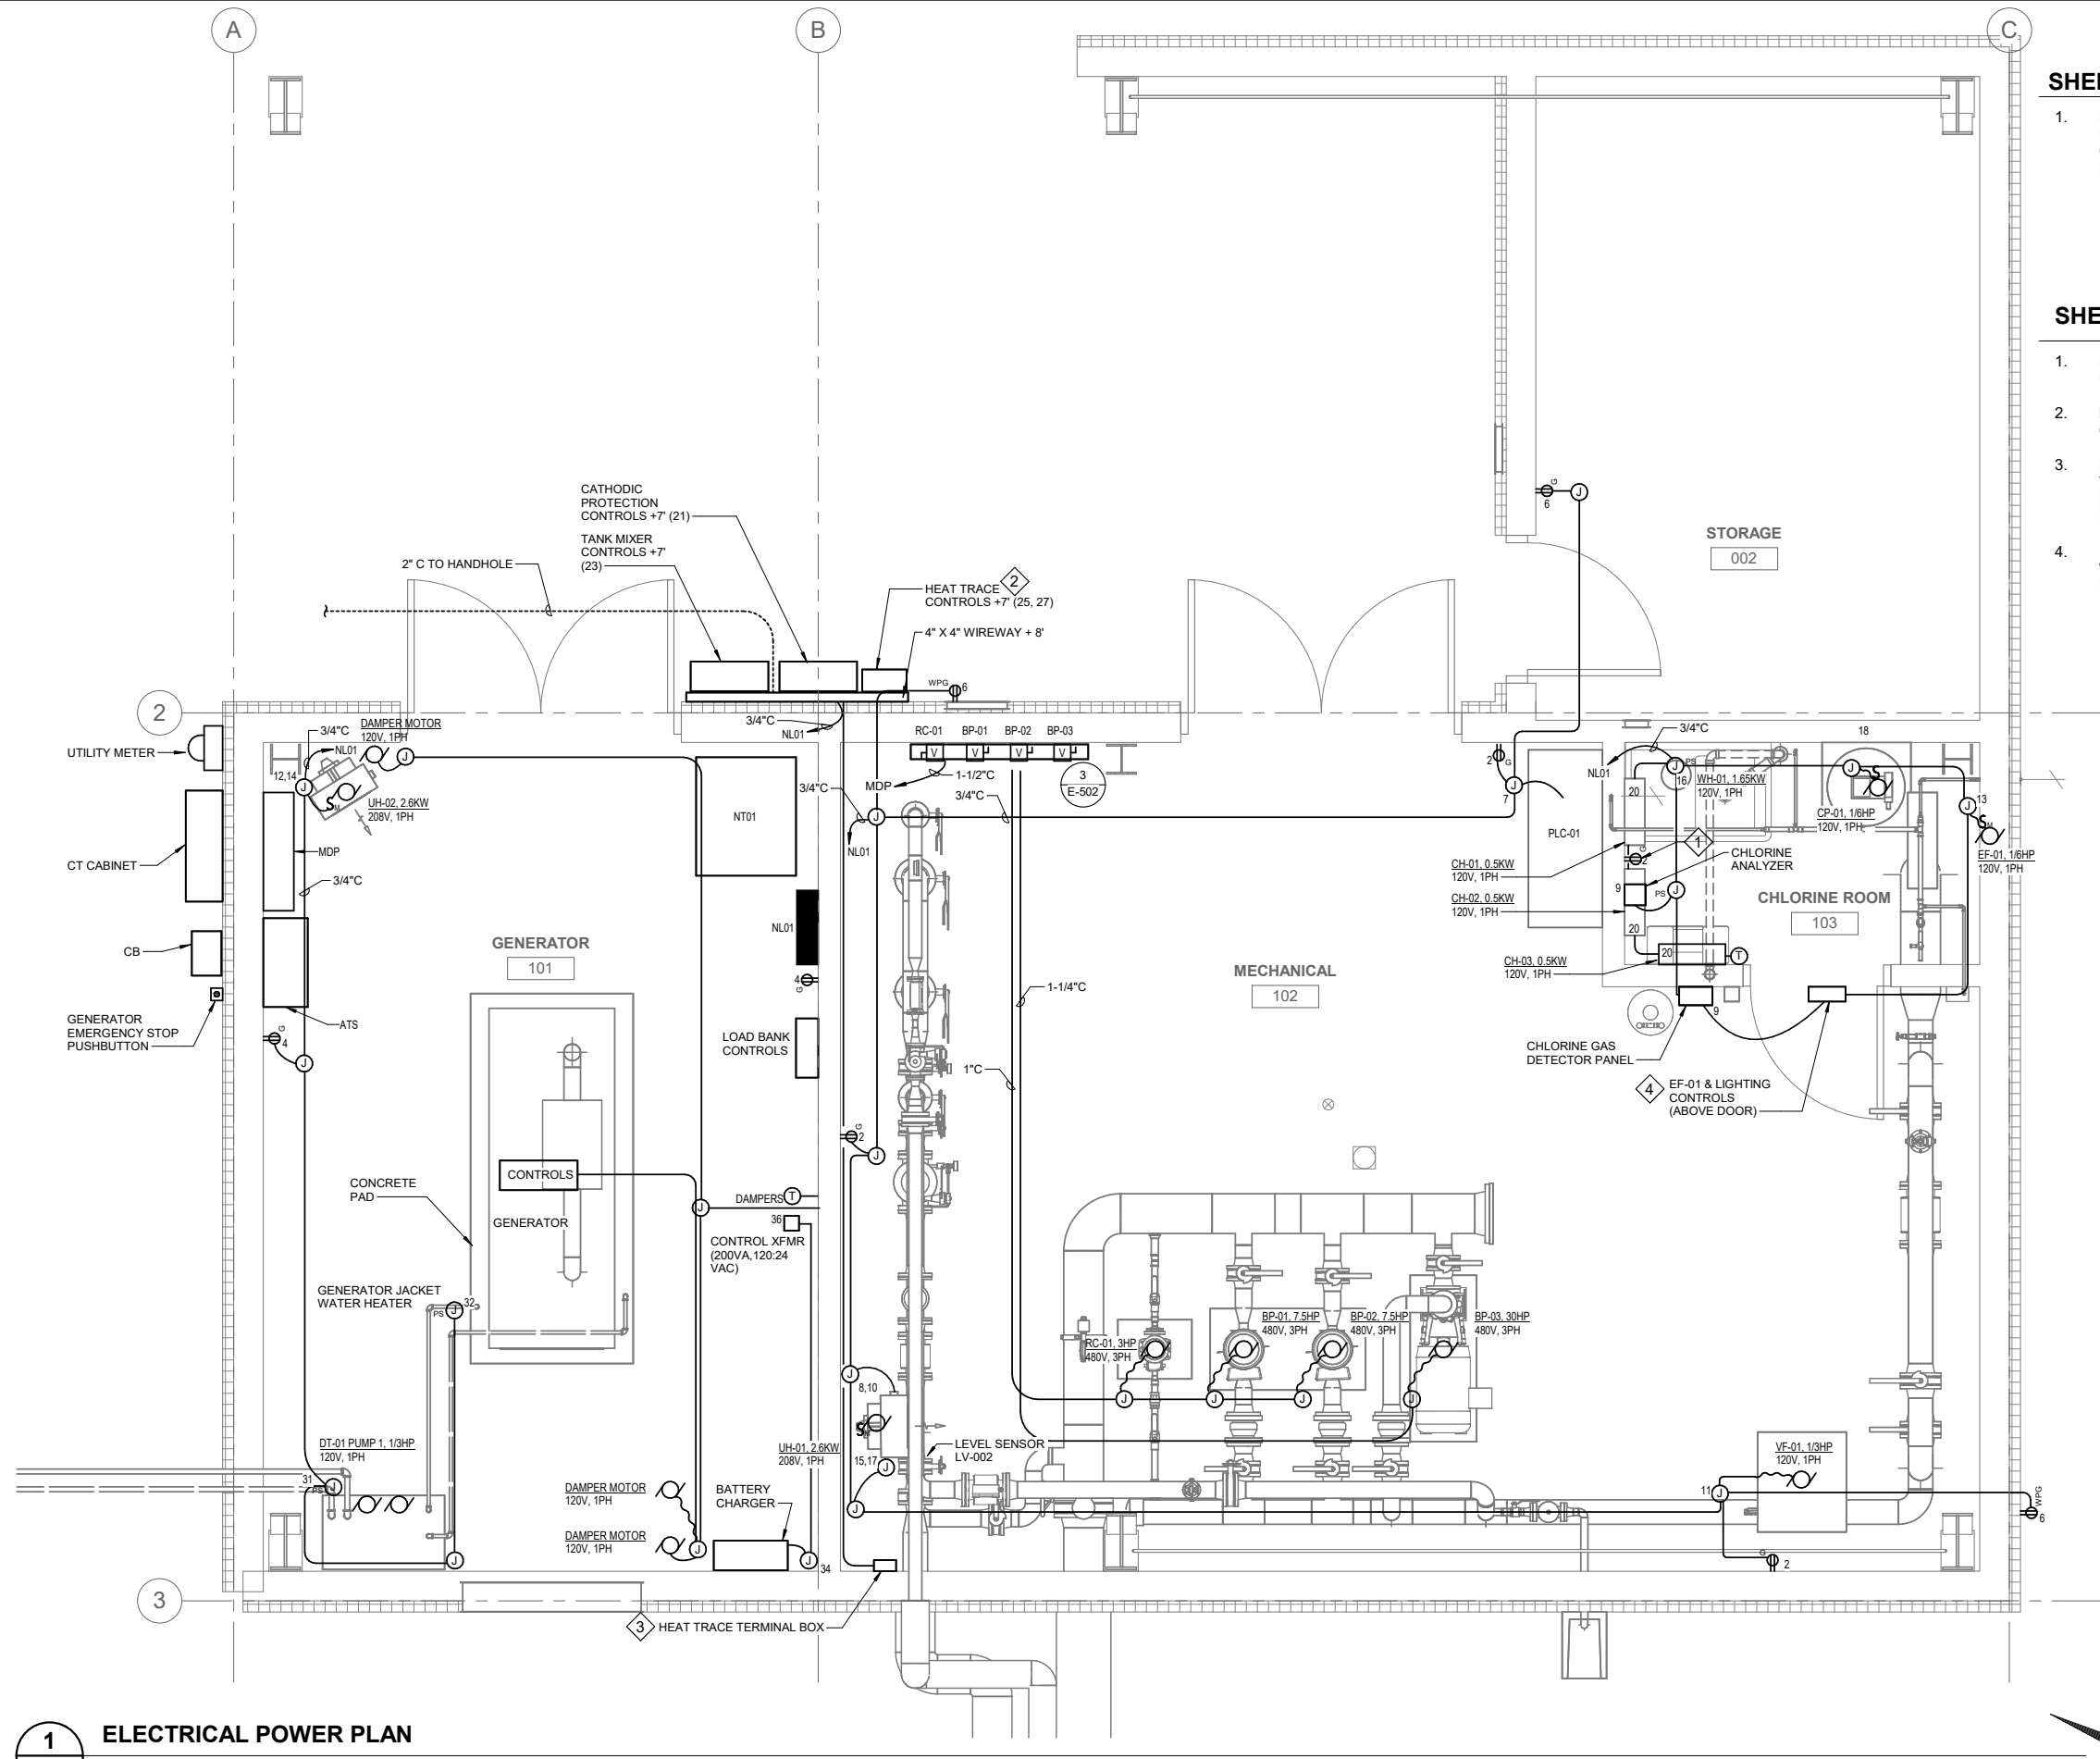


SHEET NOTES

1. PROVIDE CORROSION RESISTANT RACEWAYS, BOXES, RECEPTACLES, ENCLOSURES, AND SWITCHES IN THE CHLORINE TREATMENT ROOM. ALL BOXES AND ENCLOSURES SHALL BE NEMA TYPE 4X.

SHEET KEYNOTES

1. PROVIDE WEATHER-PROOF, CORROSION RESISTANT RECEPTACLE INSIDE CHLORINE TREATMENT ROOM.
2. LOCATE THE REMOTE TEMPERATURE SENSOR IN AN OPEN 1" STEEL BELOW THE CONTROL PANEL.
3. PROVIDE HEAT TRACE BENEATH THE INSULATION ON THE 3", 6", AND 10" PIPES FROM INSIDE THE MECHANICAL ROOM TO THE WATER STORAGE TANK. REFER TO THE HEAT TRACE SCHEMATIC DIAGRAM.
4. INTEGRATE THE CONTROLS FOR EXHAUST FAN EF-01 WITH THE LIGHTING FOR THE ROOM. REFER TO SHEETS E-111 AND E-502.

CONSULTANT :

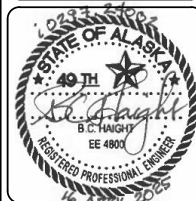

Juneau, AK
9103 Mendocino Mall Rd. Ste 4
Juneau, AK 99801
Phone: 907.780.6060
www.respec.com
AEC0163270

RESPEC

PROJECT :
**CITY & BOROUGH OF YAKUTAT
WATER SYSTEM EXTENSION**

YAKUTAT, ALASKA

SHEET TITLE :
ELECTRICAL FLOOR PLAN - POWER

DESIGN	NK
DRAWN	CSB
CHECKED	BCH
DATE	04-16-2025

PROJECT No.
10297.24002

SHEET NUMBER
E-112

No.	Date	Item
REVISIONS		