


4/17/2025 1:11:27 PM Autodesk Docs/10297.24002/CBY Airport Water System Extension/INF-MECH-10297.24002_RV23.rvt IF THIS BAR DOES NOT MEASURE EXACTLY ONE INCH, THE SCALE OF THIS DRAWING HAS BEEN ALTERED DURING ITS PRODUCTION, AFFECTING ALL LABELED SCALES 1"

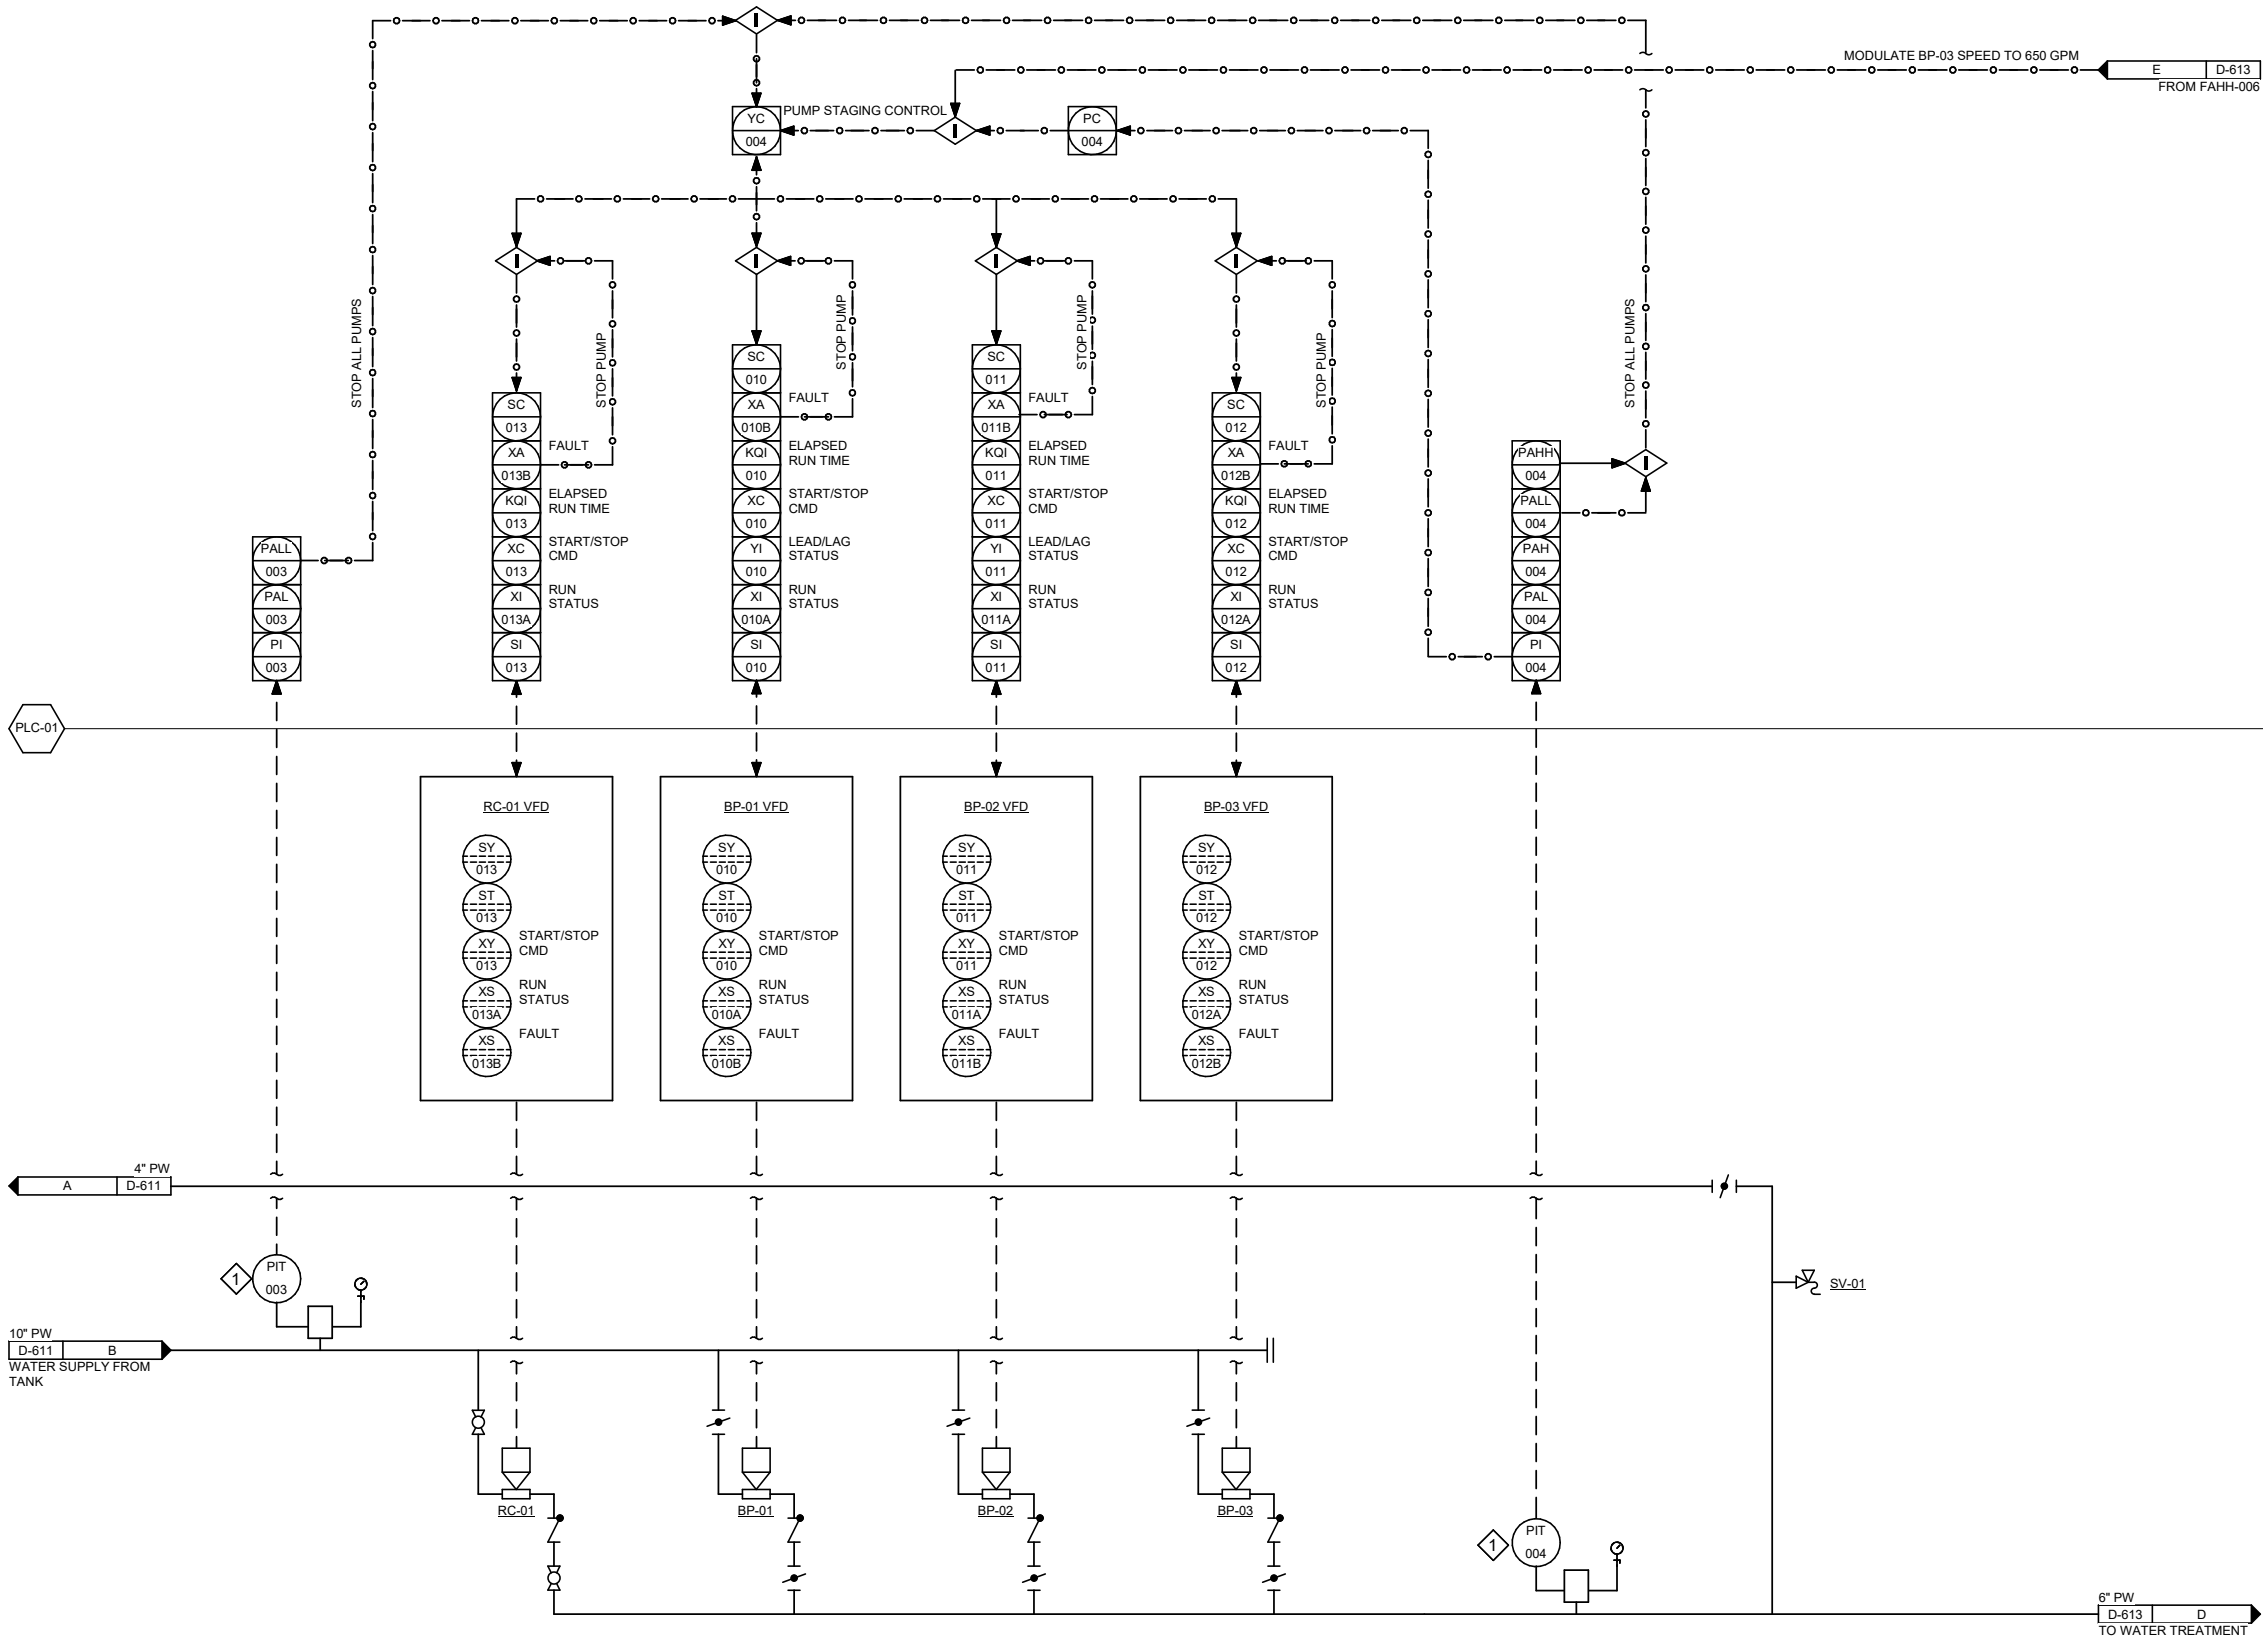

1 PUMP WATER P&ID
D-612 SCALE: NO SCALE

SHEET KEYNOTES #

- SEE DETAIL 4 / SHEET D-511 FOR PRESSURE INDICATOR / TRANSMITTER ASSEMBLY DETAIL.



Juneau, AK
9103 Mendelton Mall Rd. Ste 4
Juneau, AK 99801
Phone: 907.780.6060
www.rspect.com
AECC163270

PROJECT :
CITY & BOROUGH OF YAKUTAT
WATER SYSTEM EXTENSION
YAKUTAT, ALASKA

SHEET TITLE :
PUMP WATER P&ID

DESIGN ALN
DRAWN TRS
CHECKED LAR
DATE 04-16-2025
PROJECT No.
10297.24002
SHEET NUMBER

D-612

No.	Date	Item
REVISIONS		