




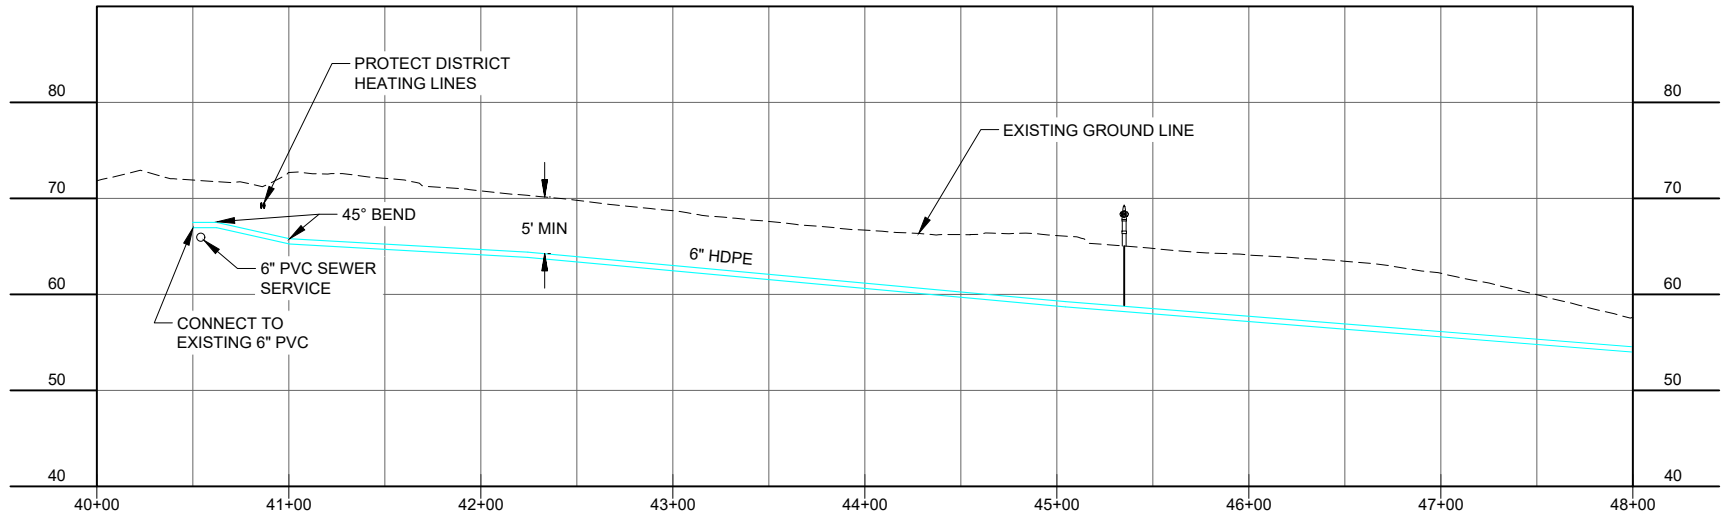

CONSULTANT :

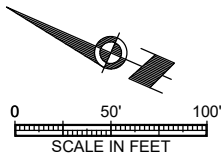

Juneau, AK
9080 Mendenhall Rd. Ste. 4
Juneau, AK 99801
Phone: 907.580.6060
Fax: 907.586.3771
AECOC 63270

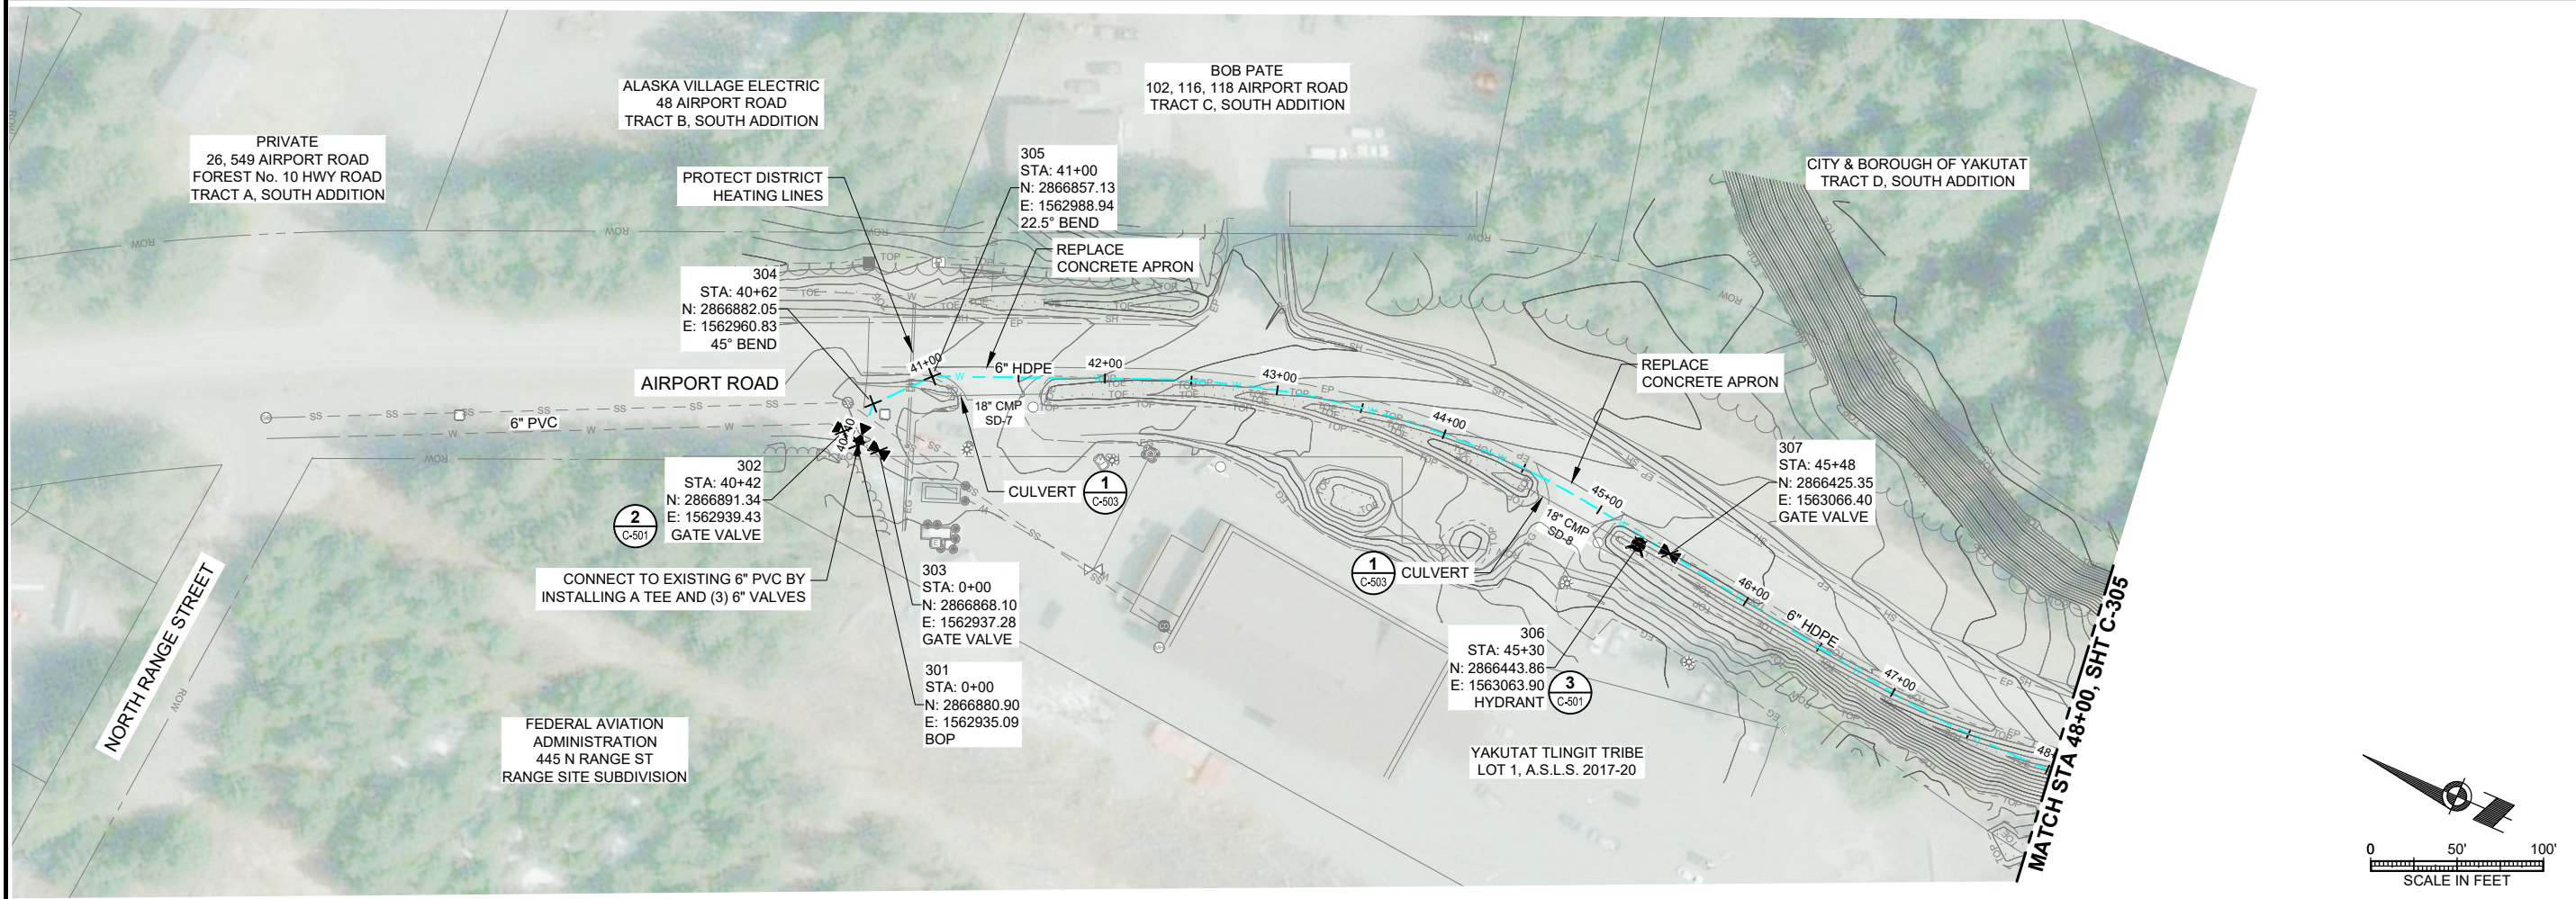

PROJECT :
CITY & BOROUGH OF YAKUTAT
WATER SYSTEM EXTENSION

YAKUTAT, ALASKA

SHEET TITLE :
PLAN AND PROFILE -
AIRPORT ROAD (1 OF 14)

DESIGN AMN
DRAWN HRB
CHECKED KAB
DATE 04-16-2025

PROJECT No.
10297.24002
SHEET NUMBER

C-304