
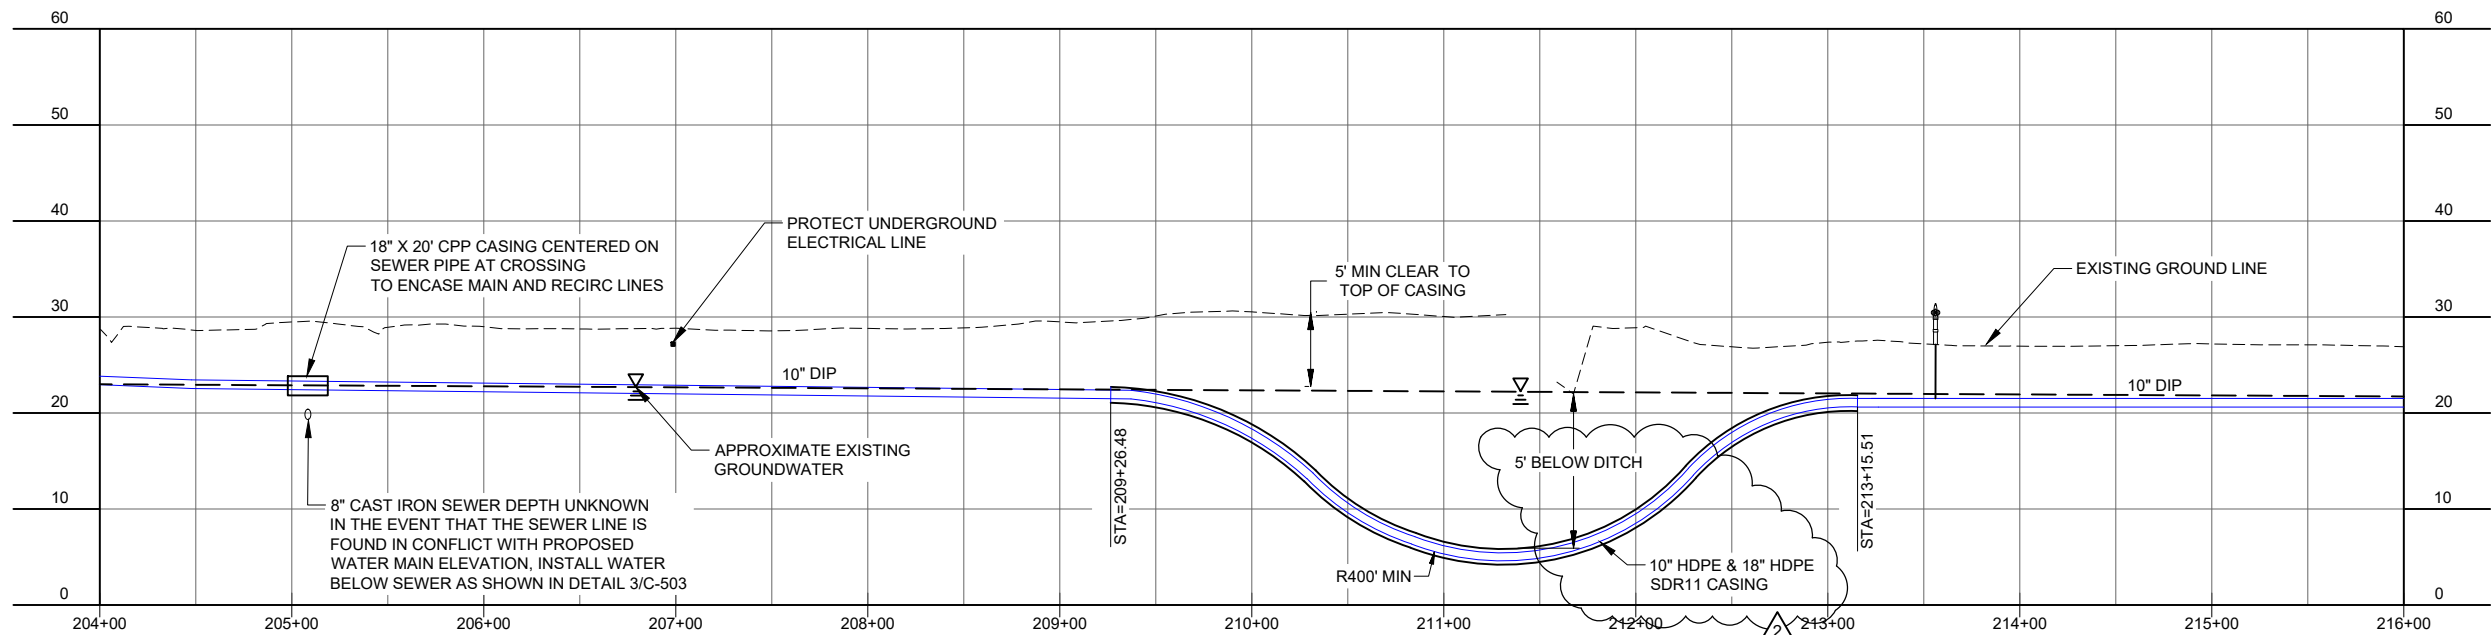


1" IF THIS BAR DOES NOT MEASURE EXACTLY ONE INCH, THE SCALE OF THIS DRAWING HAS BEEN ALTERED DURING ITS PRODUCTION, AFFECTING ALL LABELED SCALES

\\projects\10297_24002_C318_Airport_Wtr_Ext\ICOLD\250505\04_Original Drawings\10297_24002_C-PlanProfileSheetHDPE C-318 Sep 24, 2025 3:25 PM

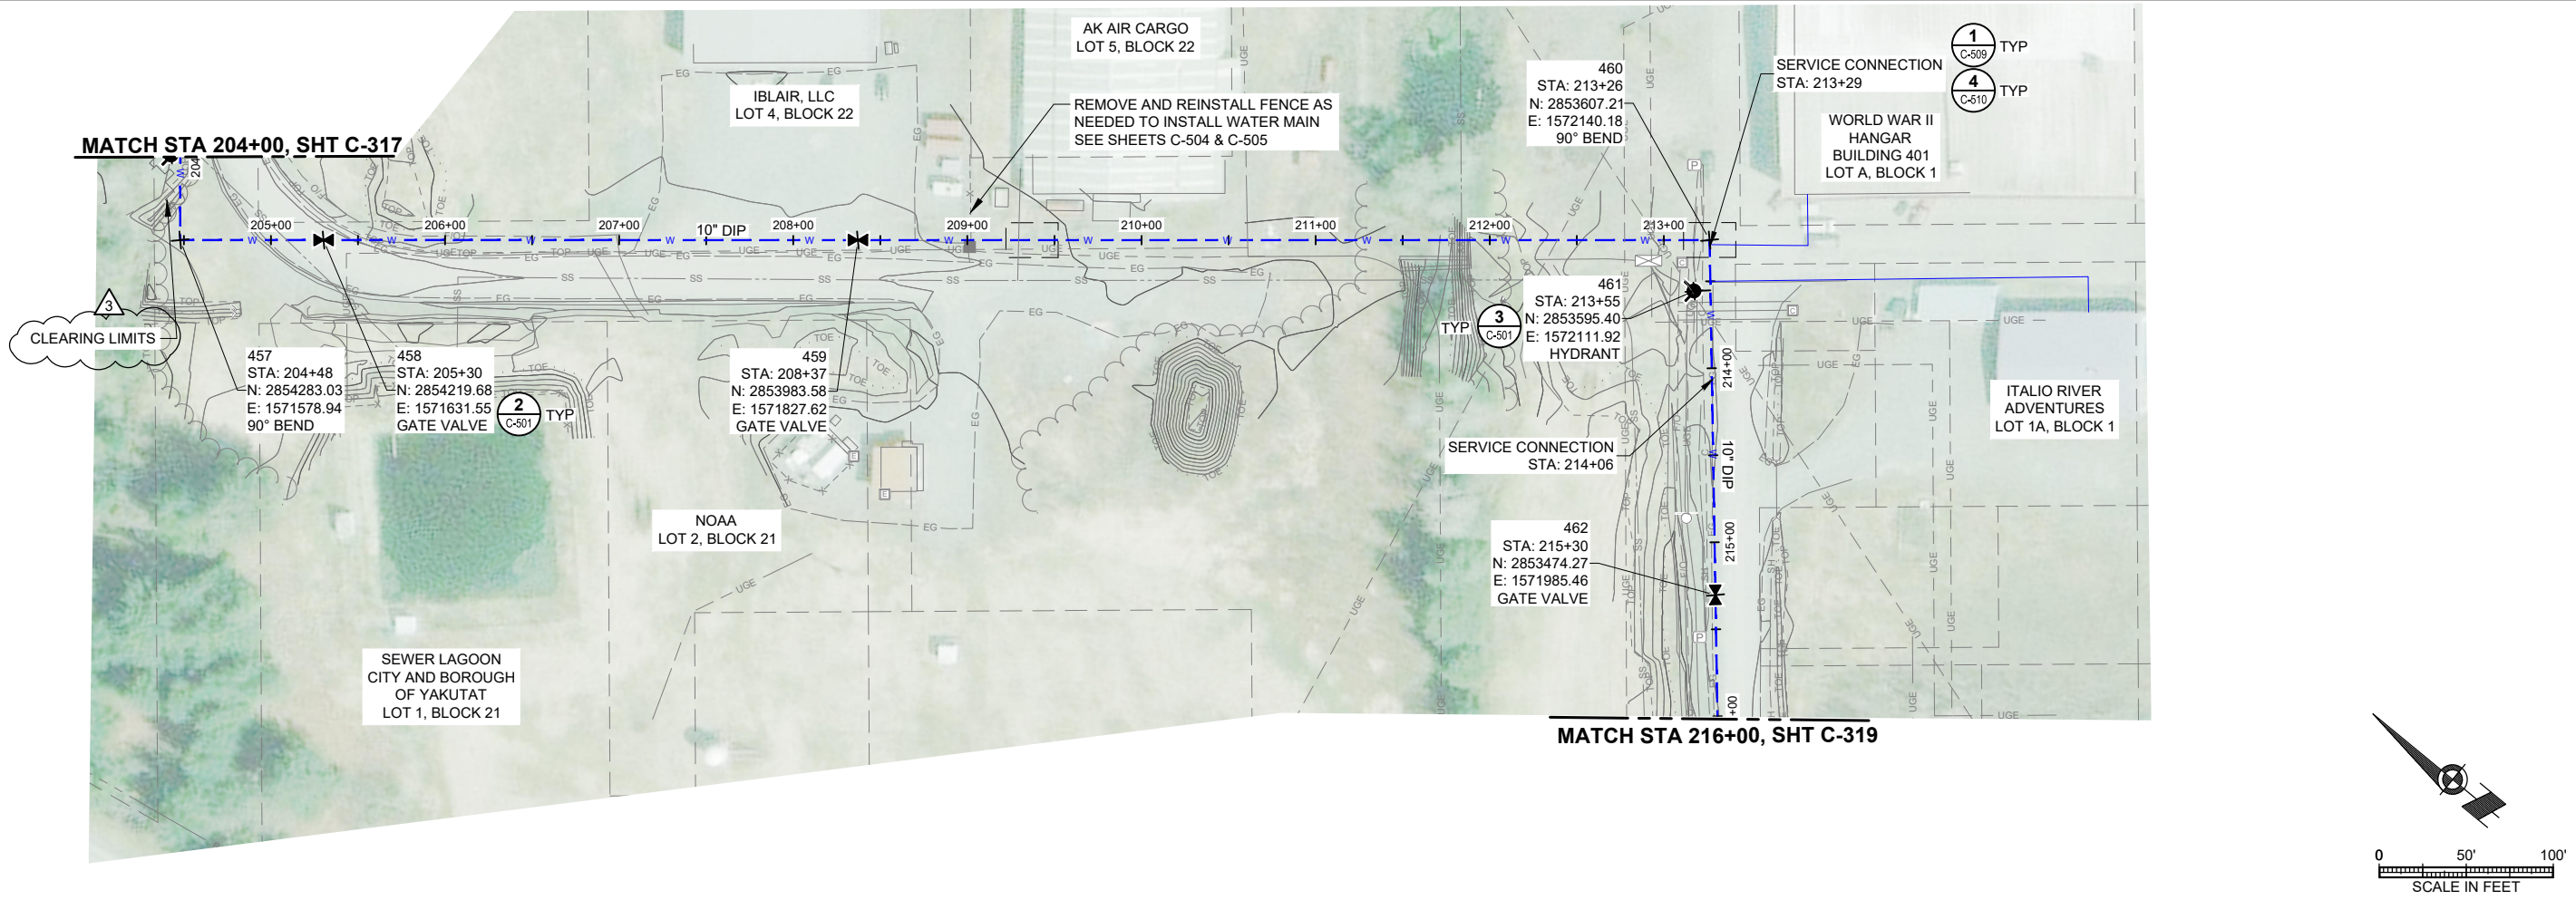

REVISIONS	
No.	Date
1	09/24/2025
2	09/16/2025
ADDENDUM No. 3	
ADDENDUM No. 2	
Item	

CONSULTANT :

STATE OF ALASKA
10297 24002
49 TH
KAREN ANN BRADY
09/24/2025
REGISTERED PROFESSIONAL ENGINEER

Juneau, AK
9109 Mendota Mall Rd. Ste. 4
Juneau, AK 99801
Phone: 907.580.6060
Fax: 907.586.3771
AEC 163270

ASPEC

PROJECT :

CITY & BOROUGH OF YAKUTAT
WATER SYSTEM EXTENSION

YAKUTAT, ALASKA

SHEET TITLE :

PLAN AND PROFILE -
AIRPORT AREA

DESIGN	AMN
DRAWN	HRB
CHECKED	KAB
DATE	04-16-2025

PROJECT No.
10297.24002

SHEET NUMBER
C-318