


9/24/2025 11:28:20 AM Autodesk Docs\\10297.24002\\CBY Airport Water System Extension\\NF-MECH-10297.24002_RV23.rvt IF THIS BAR DOES NOT MEASURE EXACTLY ONE INCH, THE SCALE OF THIS DRAWING HAS BEEN ALTERED DURING ITS PRODUCTION. AFFECTING ALL LABELED SCALES 1"

1

D-111

PROCESS SITE PLAN

SCALE: 1/4" = 1'-0"

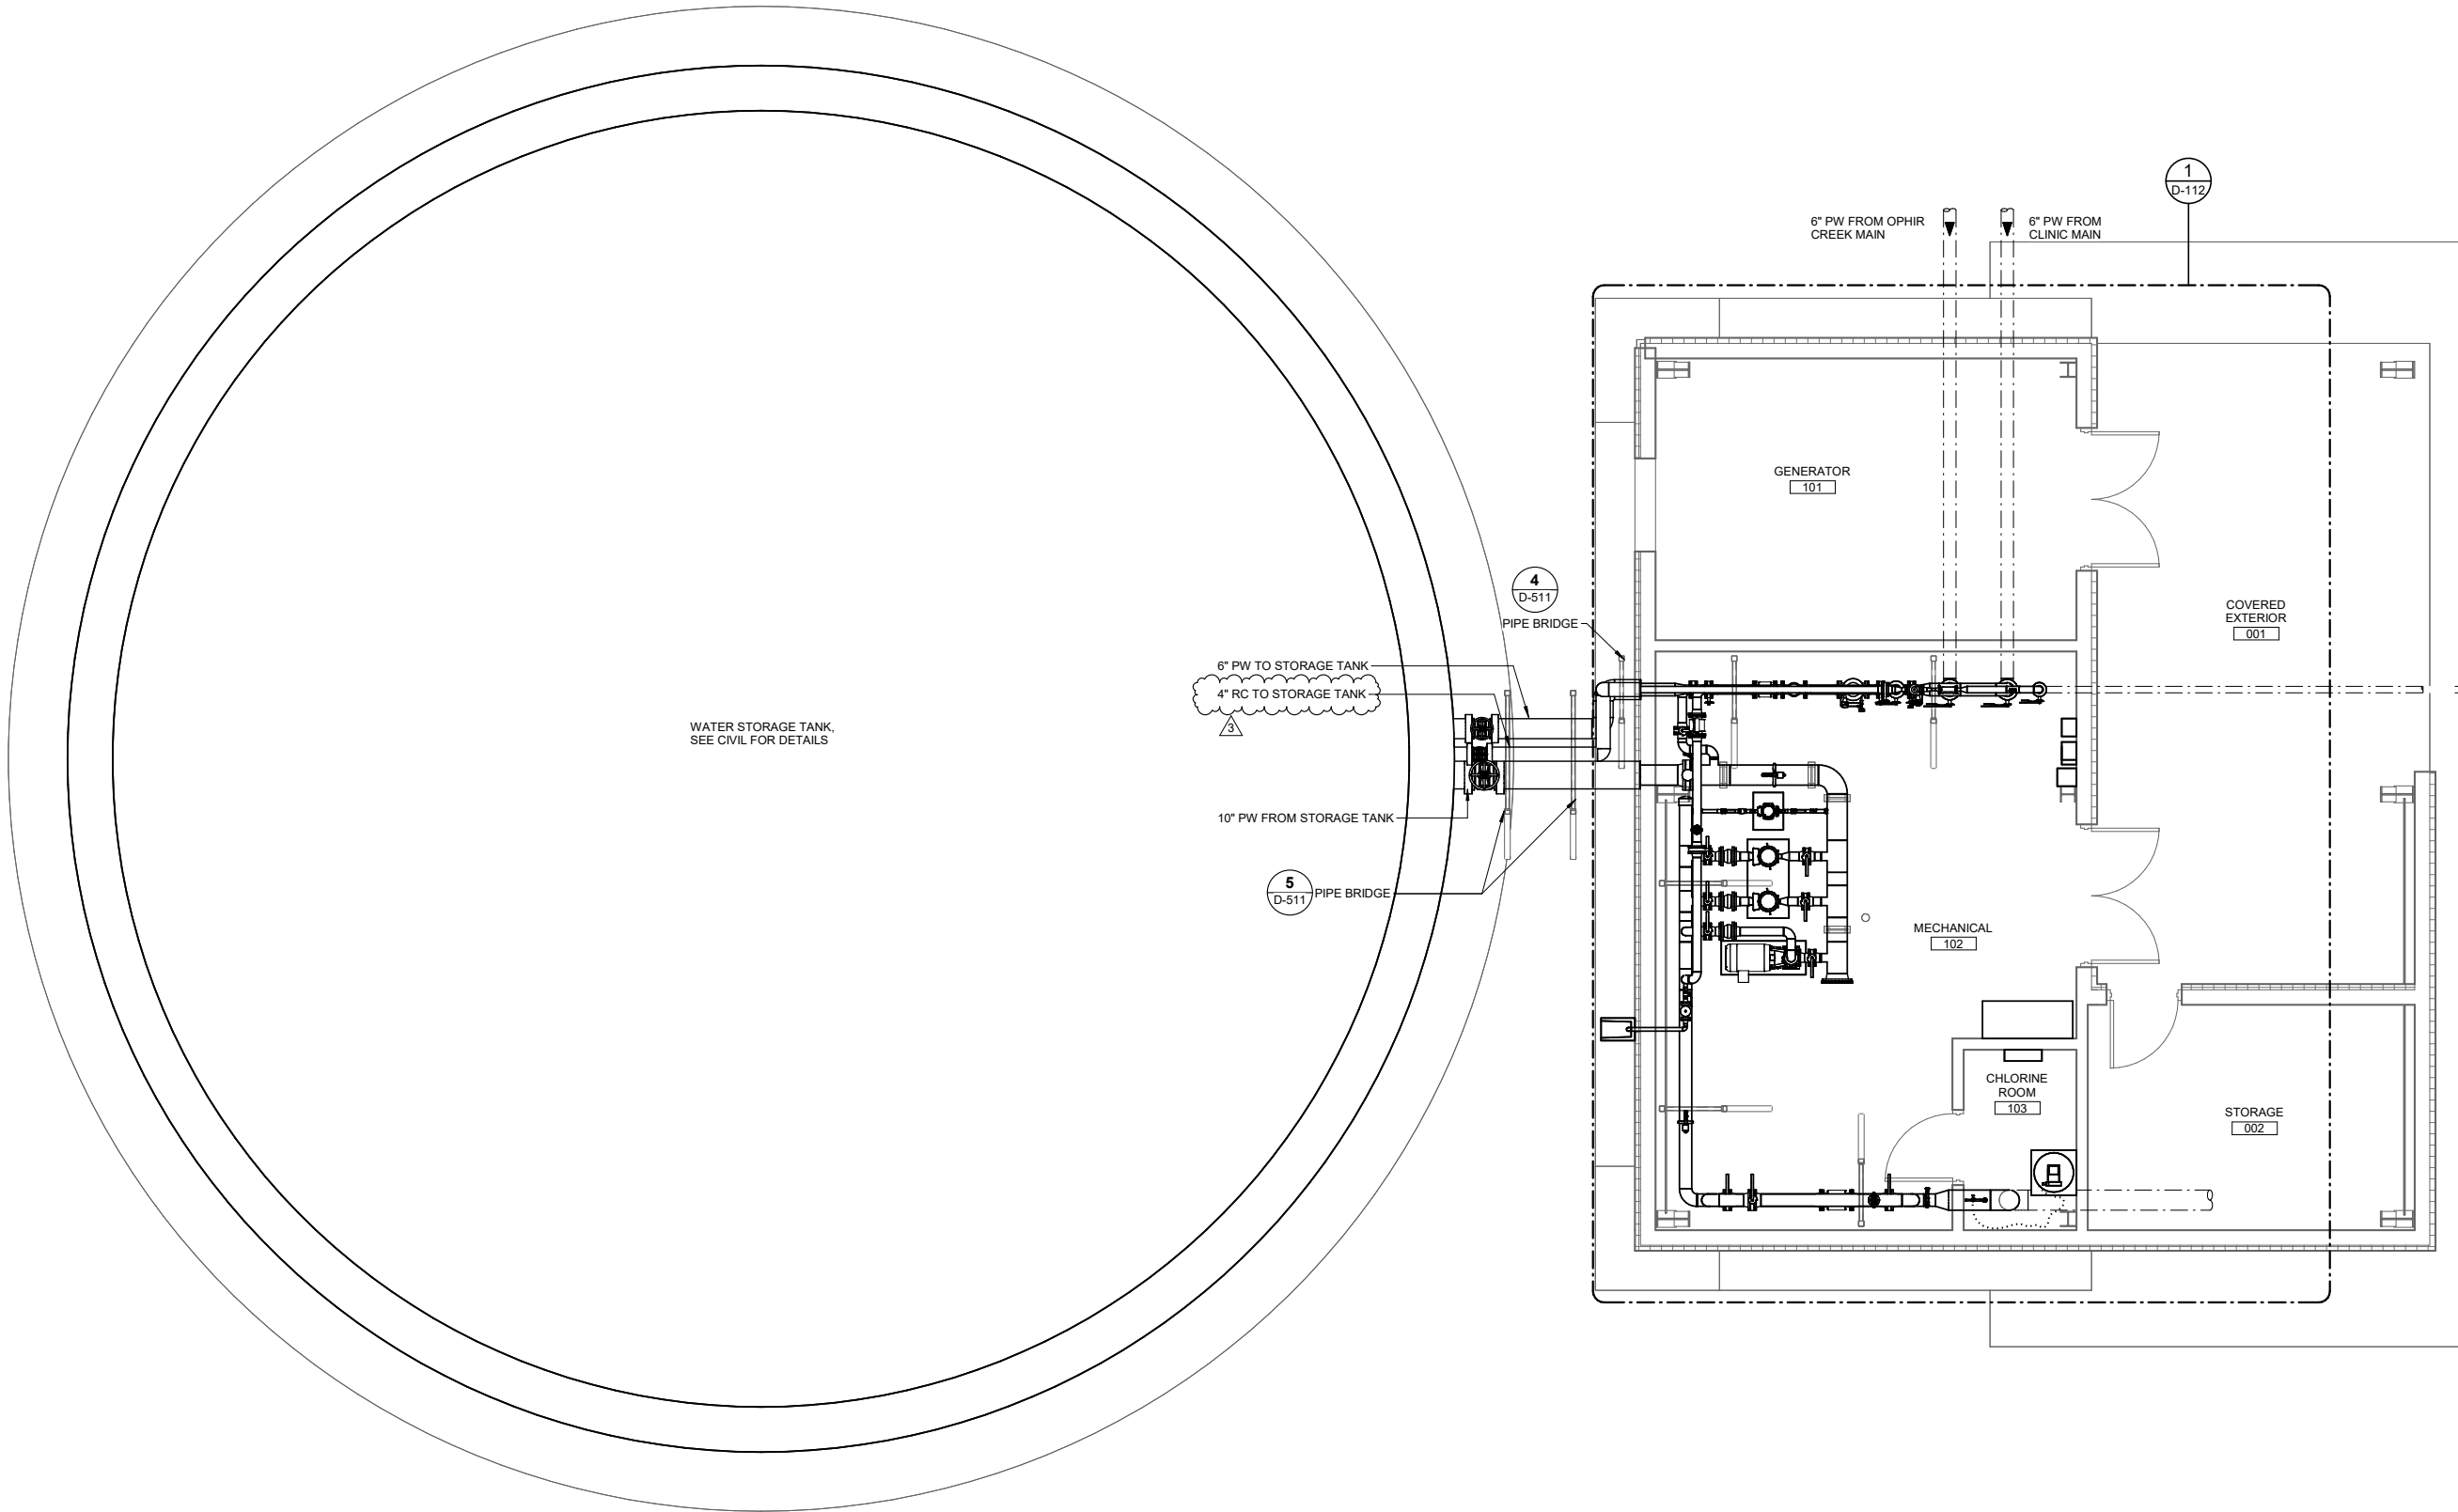

REVISIONS			
No.	Date	Item	
3	9/24/25	ADDENDUM #3	

DESIGN	ALN
DRAWN	TRS
CHECKED	LAR
DATE	04-16-2025
PROJECT No. 10297.24002	
SHEET NUMBER	

D-111

SHEET TITLE :
SITE PLAN - PROCESS

PROJECT :
CITY & BOROUGH OF YAKUTAT
WATER SYSTEM EXTENSION

YAKUTAT, ALASKA

Juneau, AK
9103 Mendenhall Mall Rd. Ste 4
Juneau, AK 99801
Phone: 907.780.6060
www.respec.com
AEC0163270



CONSULTANT :