


9/24/2025 11:28:24 AM AutoCAD Doc://10297.24002-CBY Airport Water System Extension/INF-MECH-10297.24002_RV23.rvt 1" IF THIS BAR DOES NOT MEASURE EXACTLY ONE INCH, THE SCALE OF THIS DRAWING HAS BEEN ALTERED DURING ITS PRODUCTION, AFFECTING ALL LABELED SCALES

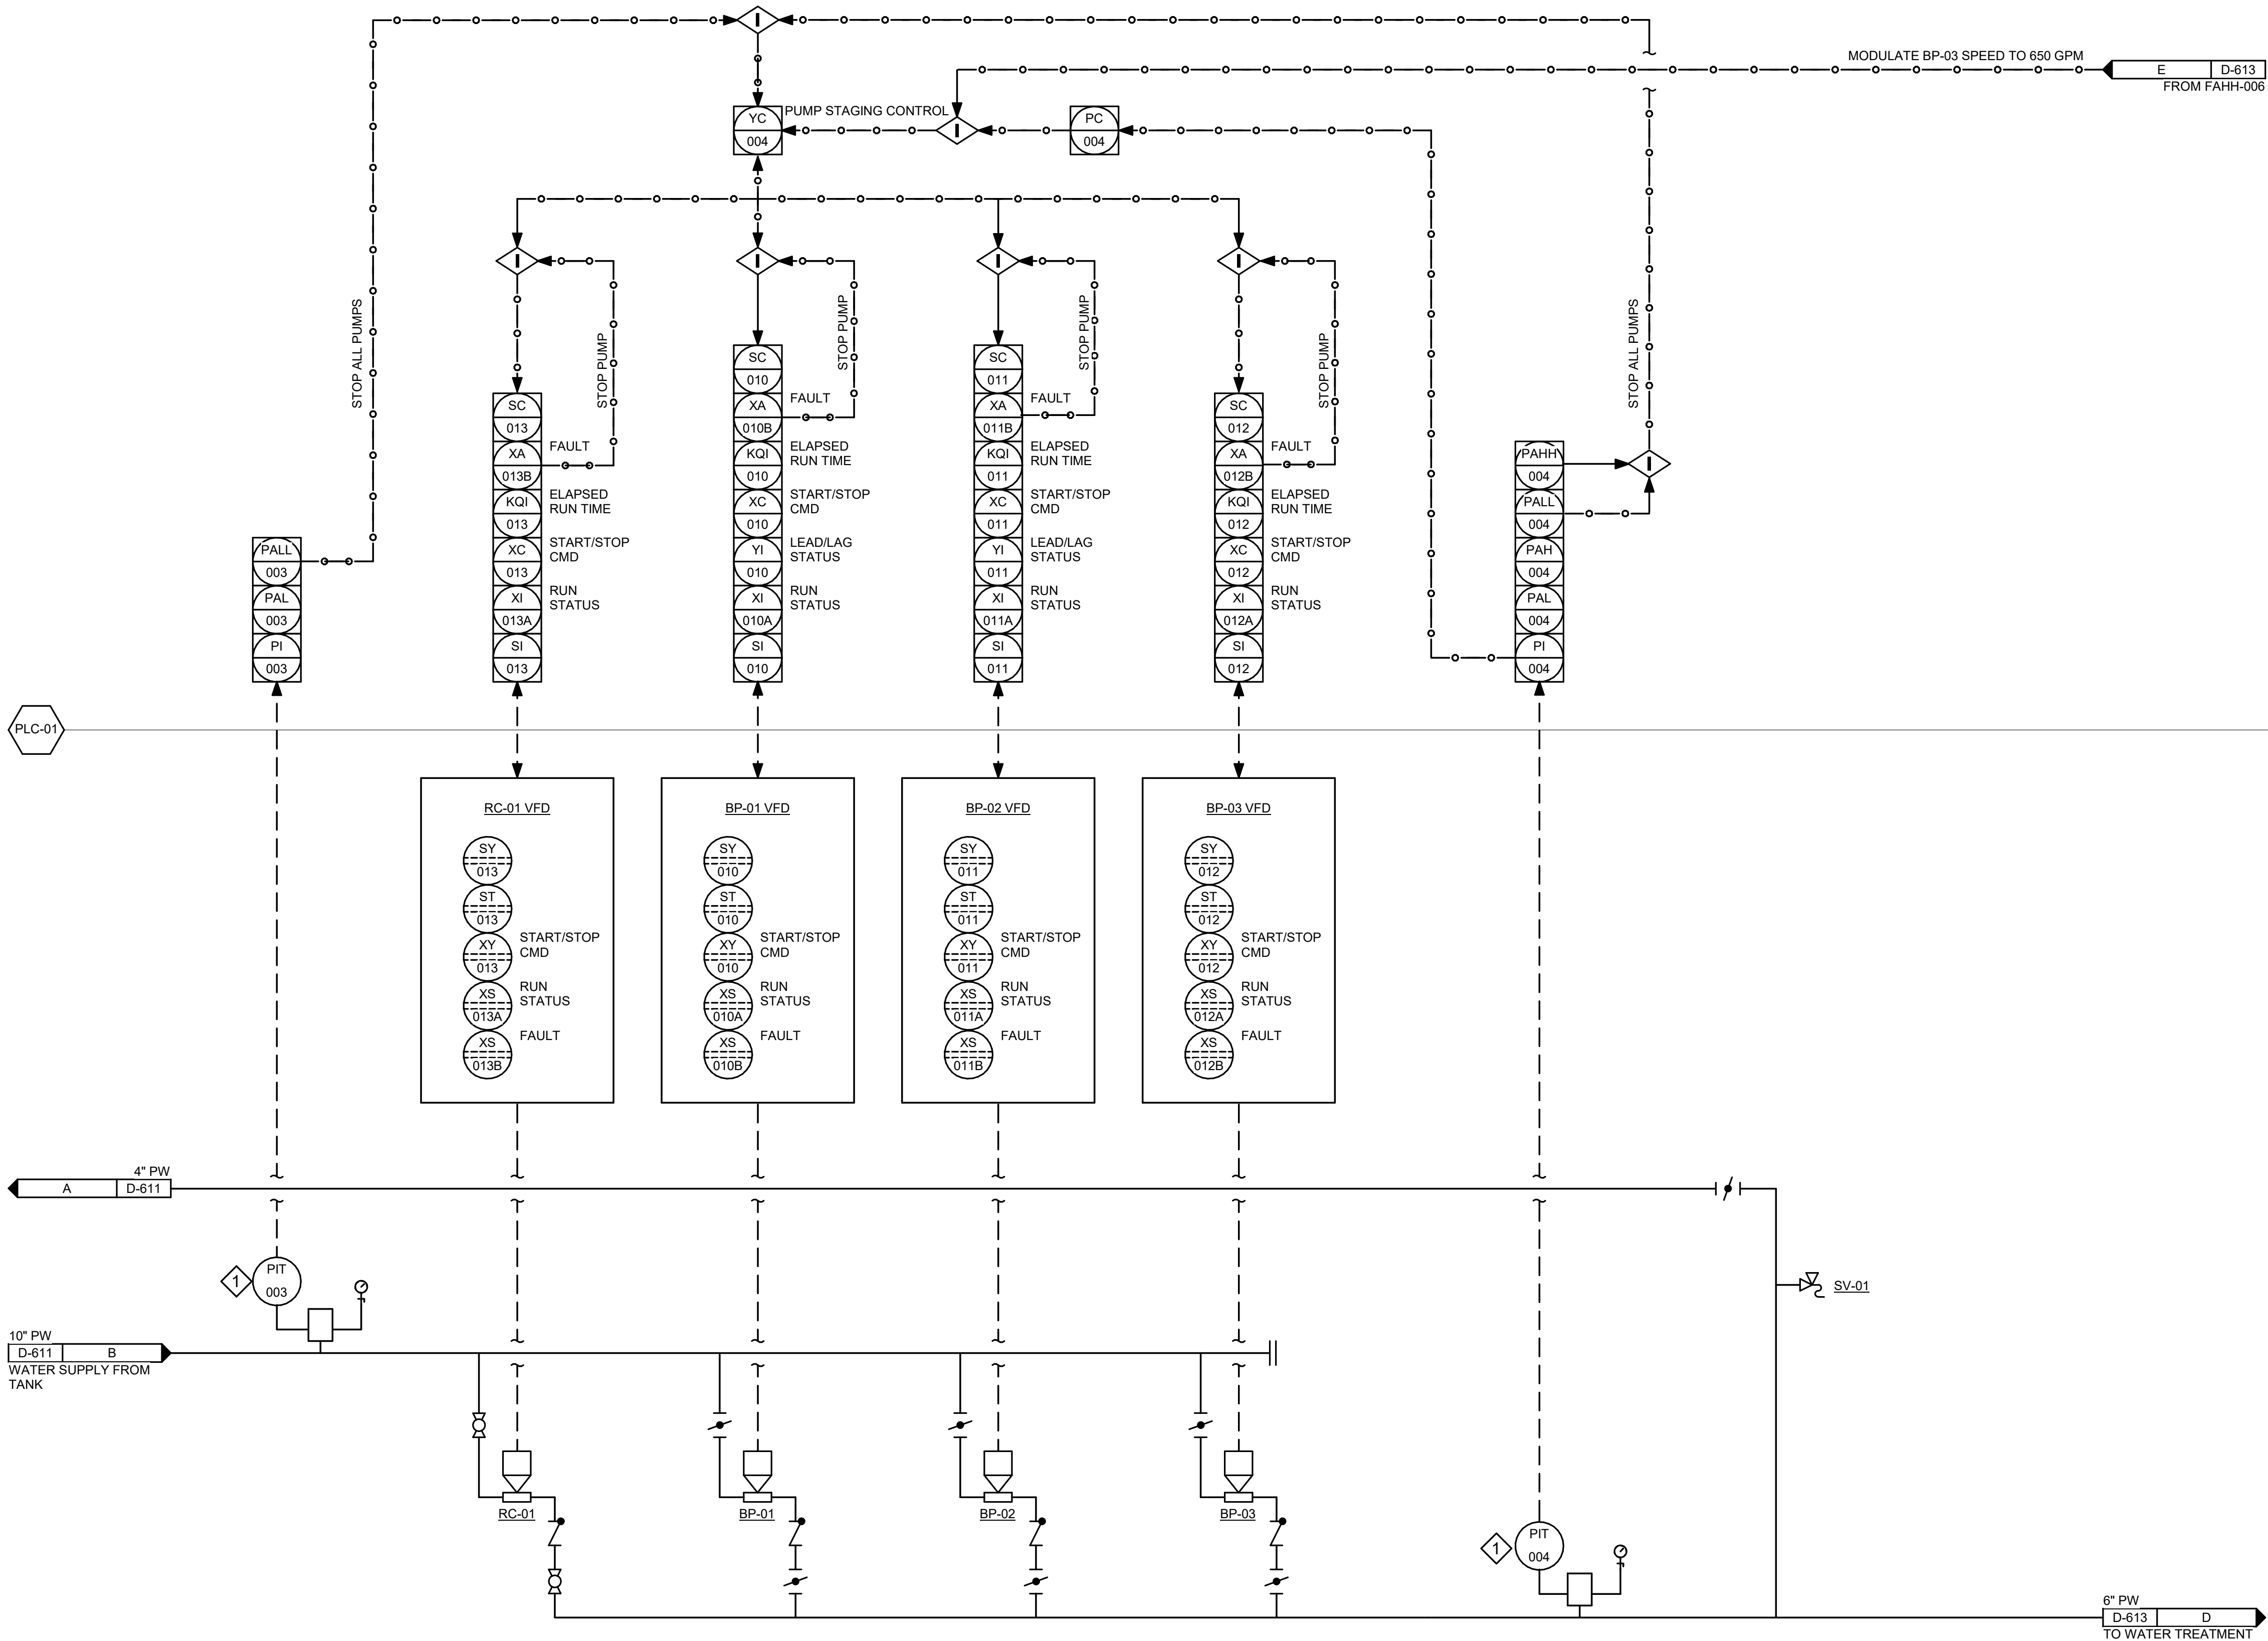

1 PUMP WATER P&ID
D-612 SCALE: NO SCALE

SHEET KEYNOTES #

- SEE DETAIL 4 / SHEET D-511 FOR PRESSURE INDICATOR / TRANSMITTER ASSEMBLY DETAIL.



Juneau, AK
9103 Mendenhall Mall Rd, Ste 4
Juneau, AK 99801
Phone: 907.780.6060
www.respec.com
AECC 63270

RESPEC

PROJECT :
**CITY & BOROUGH OF YAKUTAT
WATER SYSTEM EXTENSION**

YAKUTAT, ALASKA

SHEET TITLE :
PUMP WATER P&ID

DESIGN ALN
DRAWN TRS
CHECKED LAR
DATE 04-16-2025

PROJECT No.
10297.24002
SHEET NUMBER

D-612

No.	Date	Item
REVISIONS		