


1" IF THIS BAR DOES NOT MEASURE EXACTLY ONE INCH, THE SCALE OF THIS DRAWING HAS BEEN ALTERED DURING ITS PRODUCTION, AFFECTING ALL LABELED SCALES

Autodesk Docs/10297.24002/CBY Airport Water System Extension/INF-MECH-10297.24002_RV23.rvt 4/17/2025 3:33:46 PM

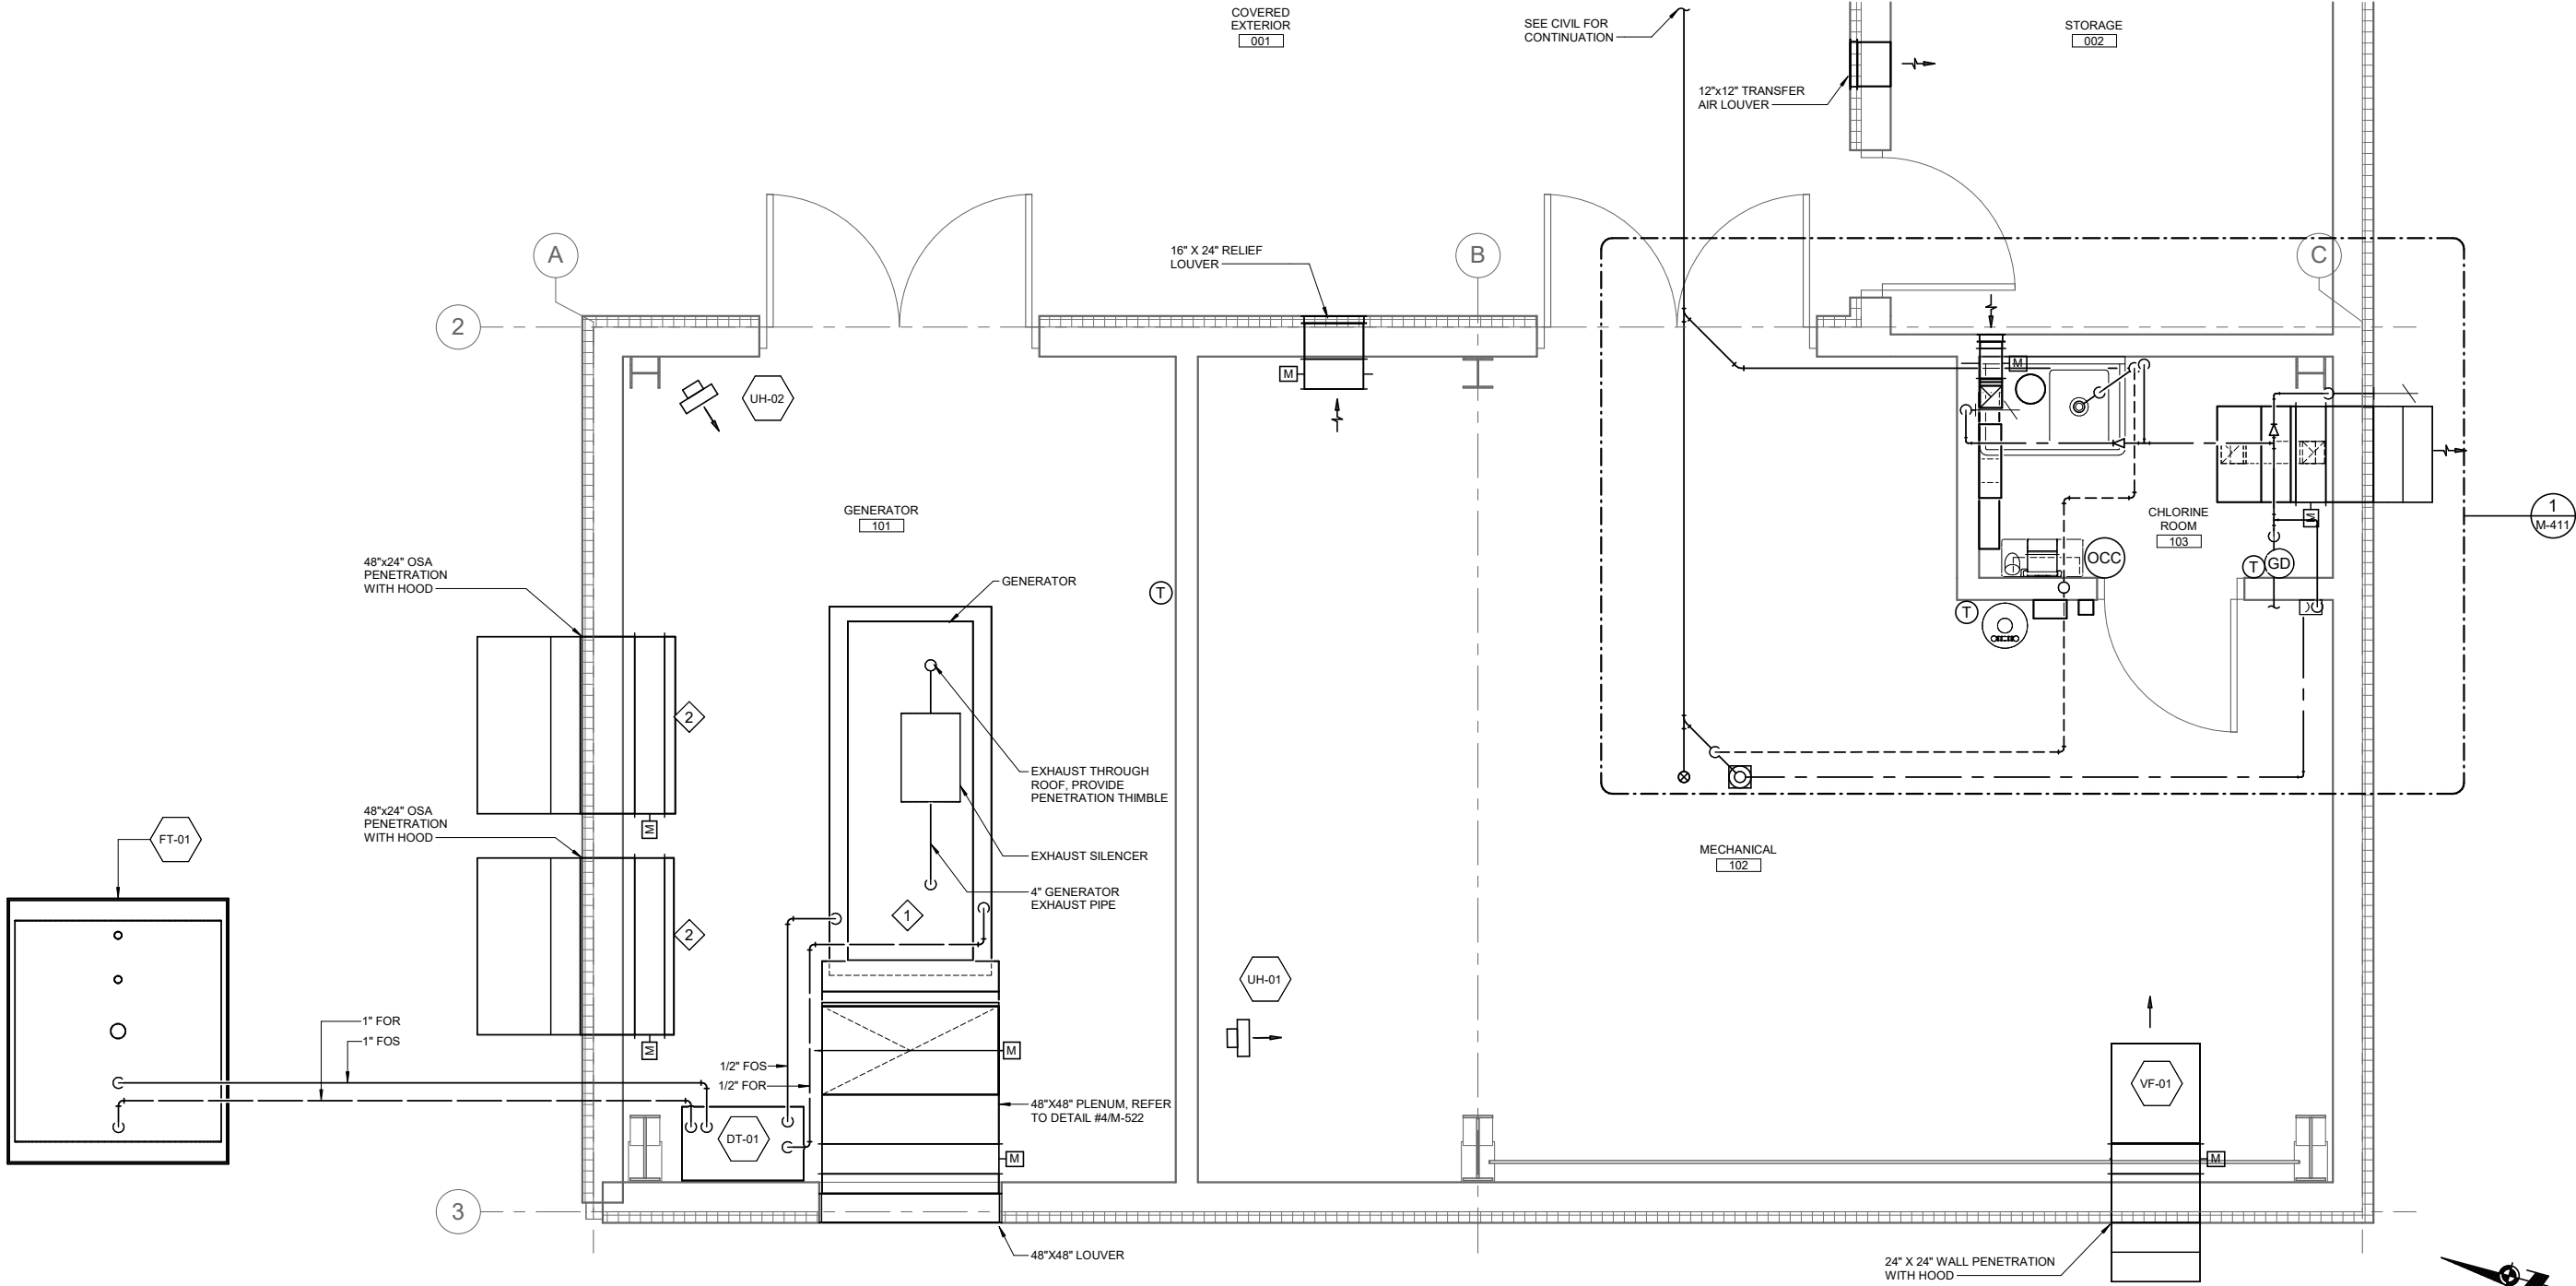

1 MECHANICAL FLOOR PLAN
SCALE: 1/2" = 1'-0"

- SHEET NOTES**
1. REFER TO PLUMBING FIXTURE CONNECTION SCHEDULE FOR INDIVIDUAL FIXTURE ROUGH-IN PIPING SIZES.
 2. PROVIDE ALL PIPING PER UPC REQUIREMENTS.
 3. PROVIDE ISOLATION VALVES AT CONNECTION TO WATER MAIN, AND AT EACH HOSE BIB AND PLUMBING FIXTURE.
 4. REFER TO SHEET M-511 FOR PLUMBING DETAILS.
 5. REFER TO SHEET M-521 FOR VENTILATION DETAILS.
 6. REFER TO SHEET M-522 FOR GENERATOR AND FUEL DETAILS.
 7. COORDINATE PIPING AND EQUIPMENT LOCATIONS WITH ELECTRICAL TRADE.
 8. AT CHLORINE ANALYZER DISCHARGE, PROVIDE FIXED AIR GAP FITTING TO WASTE CONNECTION.

- SHEET KEYNOTES** #
1. REFERENCE ELECTRICAL FOR GENERATOR SPECIFICATIONS. CONTRACTOR TO COORDINATE ALL PIPING, EXHAUST, AND DUCT CONNECTION SIZES OF THE GENERATOR UNIT SUPPLIED.
 2. 48"x24" MAKE UP AIR. REFER TO DETAIL # 7/M-521. GENERATOR MAKE UP AIR OPENING DIMENSIONS SHALL BE COORDINATED AND ADJUSTED AS REQUIRED FOR GENERATOR UNIT SUPPLIED.

No.	Date	Item
REVISIONS		

CONSULTANT :

Juneau, AK
9103 Mendenhall Mall Rd. Ste 4
Juneau, AK 99801
Phone: 907.780.6060
www.respec.com
AECC163270

PROJECT :

**CITY & BOROUGH OF YAKUTAT
WATER SYSTEM EXTENSION**

YAKUTAT, ALASKA

SHEET TITLE :

**PUMP HOUSE FLOOR PLAN -
MECHANICAL**

DESIGN	RM
DRAWN	TRS
CHECKED	LAR
DATE	04-16-2025

PROJECT No.
10297.24002
SHEET NUMBER

M-111