

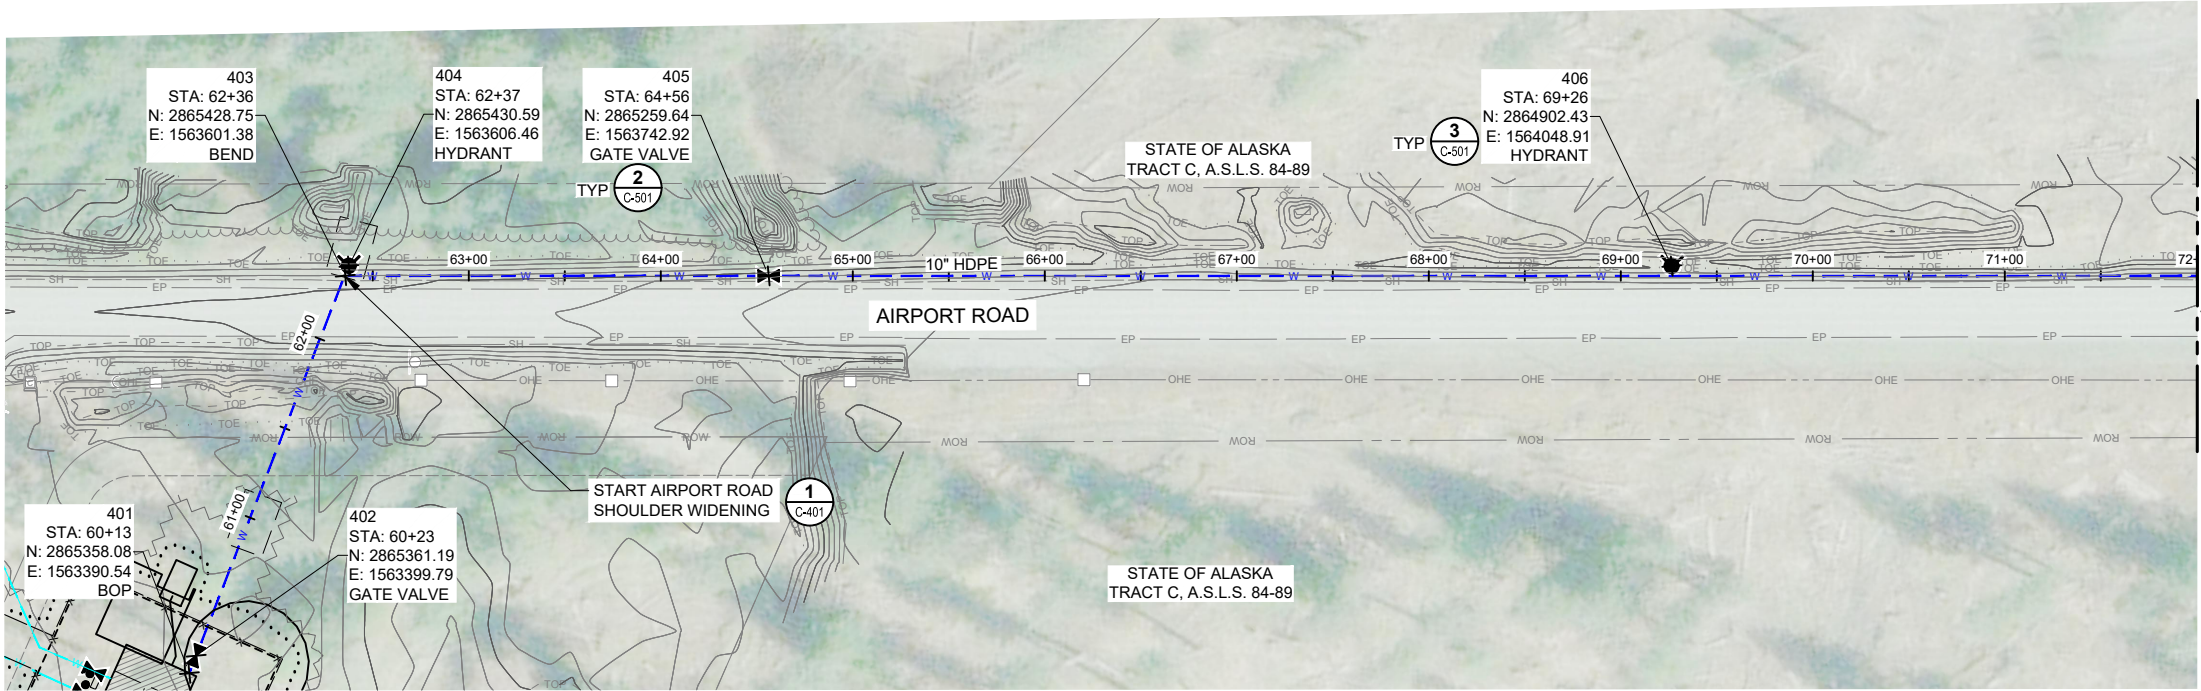


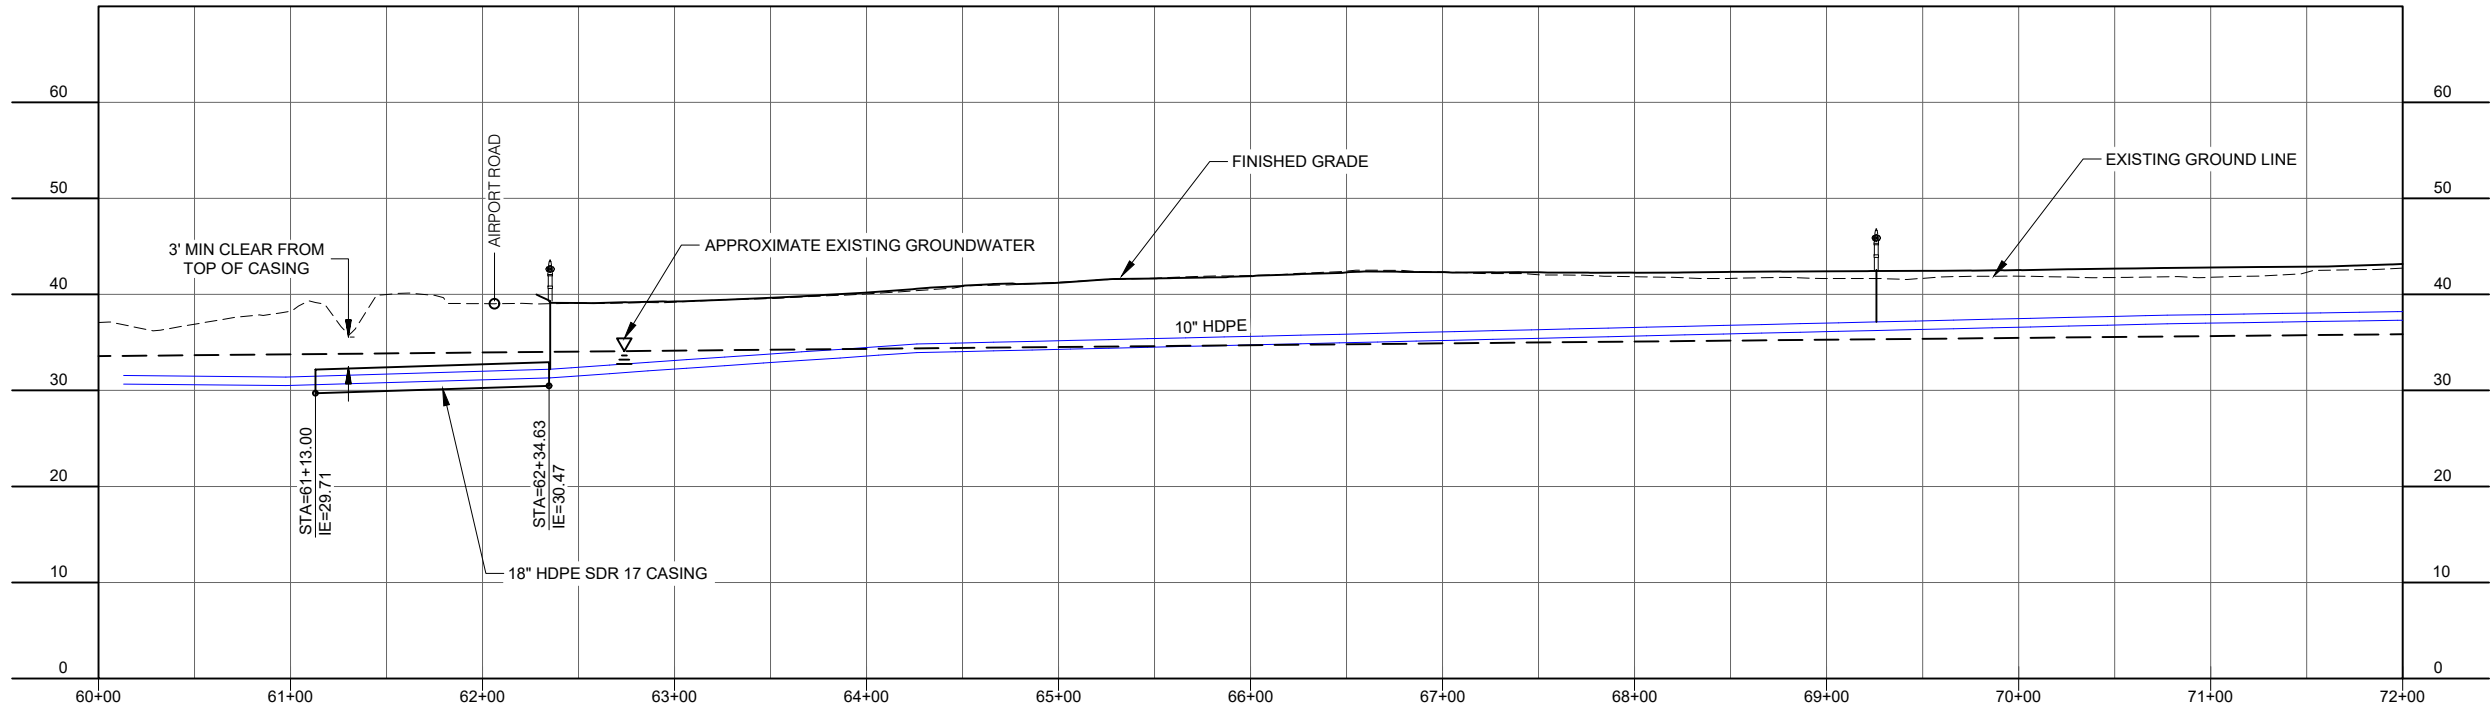

MATCH STA 72+00. SHT C-307

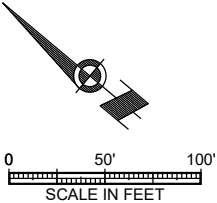

CONSULTANT :

STATE OF ALASKA
10297.24002
49 TH
Karen Ann Brady
KAREN ANN BRADY
04/16/2025
CE 11523
REGISTERED PROFESSIONAL ENGINEER

Juneau, AK
9109 Mendota Mall Rd. Ste. 4
Juneau, AK 99801
Phone: 907.586.0060
Fax: 907.586.3771
AECOC 63270

ASPEC

PROJECT :

CITY & BOROUGH OF YAKUTAT
WATER SYSTEM EXTENSION

YAKUTAT, ALASKA

SHEET TITLE :

PLAN AND PROFILE -
AIRPORT ROAD (3 OF 14)

DESIGN	AMN
DRAWN	HRB
CHECKED	KAB
DATE	04-16-2025

PROJECT No.
10297.24002

SHEET NUMBER
C-306